



TIMBER COURT
127 ANDERSON STREET
PITTSBURGH, PA 15212-6801
(412) 321-5555
(412) 321-2431 FAX

ASSOCIATE ARCHITECT



WBCM, - Architects
Whitney Bailey Cox &
Magnani, LLC
Consulting Engineers
849 Fairmount Ave. Suite 100
Baltimore, MD 21286 (410) 512-4500

Henry Adams, LLC.



600 Baltimore Avenue
Baltimore, MD 21204-4079
410.296.6500
Fax 410.296.3156

Mullins
Engineering Co.

1227 ANAPOLIS ROAD
GANTTOWN, MD 21113
410-519-0800
FAX 410-519-3971
MEC PROJECT NO. 0512300

20	1/29/10	RECORD DRAWING
19	8/14/09	BULLETIN #101
18	4/29/09	BULLETIN #100
17	4/20/09	BULLETIN #100
16	3/30/09	BULLETIN #100
15	4/15/09	BULLETIN #100
14	3/2/09	BULLETIN #100
13	12/16/08	BULLETIN #100
12	12/7/08	BULLETIN #100
11	11/20/08	BULLETIN #100
10	11/19/08	BULLETIN #100 (rev)
9	10/20/08	BULLETIN #100
8	9/4/08	BULLETIN #100
7	7/28/08	BULLETIN #100
6	6/23/08	BULLETIN #100
5	05/23/08	COORD. DWGS RFI 103
4	05/09/08	CBM-1
3	04/14/08	CBM-2
2	03/10/08	CBM-2
1	02/18/08	CBM-1
0	05/02/07	For Construction
Rev.	Date:	Comment:
Issued: May 2, 2007		

Campus Center

621 West Lombard Street
University of Maryland,
Baltimore
Baltimore, MD

Ductwork Third Floor


100% CONSTRUCTION
DOCUMENTS

UMB PROJECT NO. 99-311
WTW PROJECT NO. 70-4091
© WTW ARCHITECTS S(edit)ME Q(4 yyyy)

H1.3

RECORD DRAWING: This record drawing has been prepared based upon information provided by others. While this information is believed to be reliable, the Design Professional has not verified its accuracy, and thus is not responsible for the accuracy or completeness of this record drawing or for any errors or omissions which may have been incorporated into it as a result of erroneous information provided by others. Those relying on this record drawing are advised to obtain independent verification of its accuracy before applying it for any purpose.

IF THIS DRAWING DOES NOT MEASURE EXACTLY 33" X 42", IT HAS BEEN REDUCED OR ENLARGED. PLEASE DO NOT SCALE THIS DRAWING.

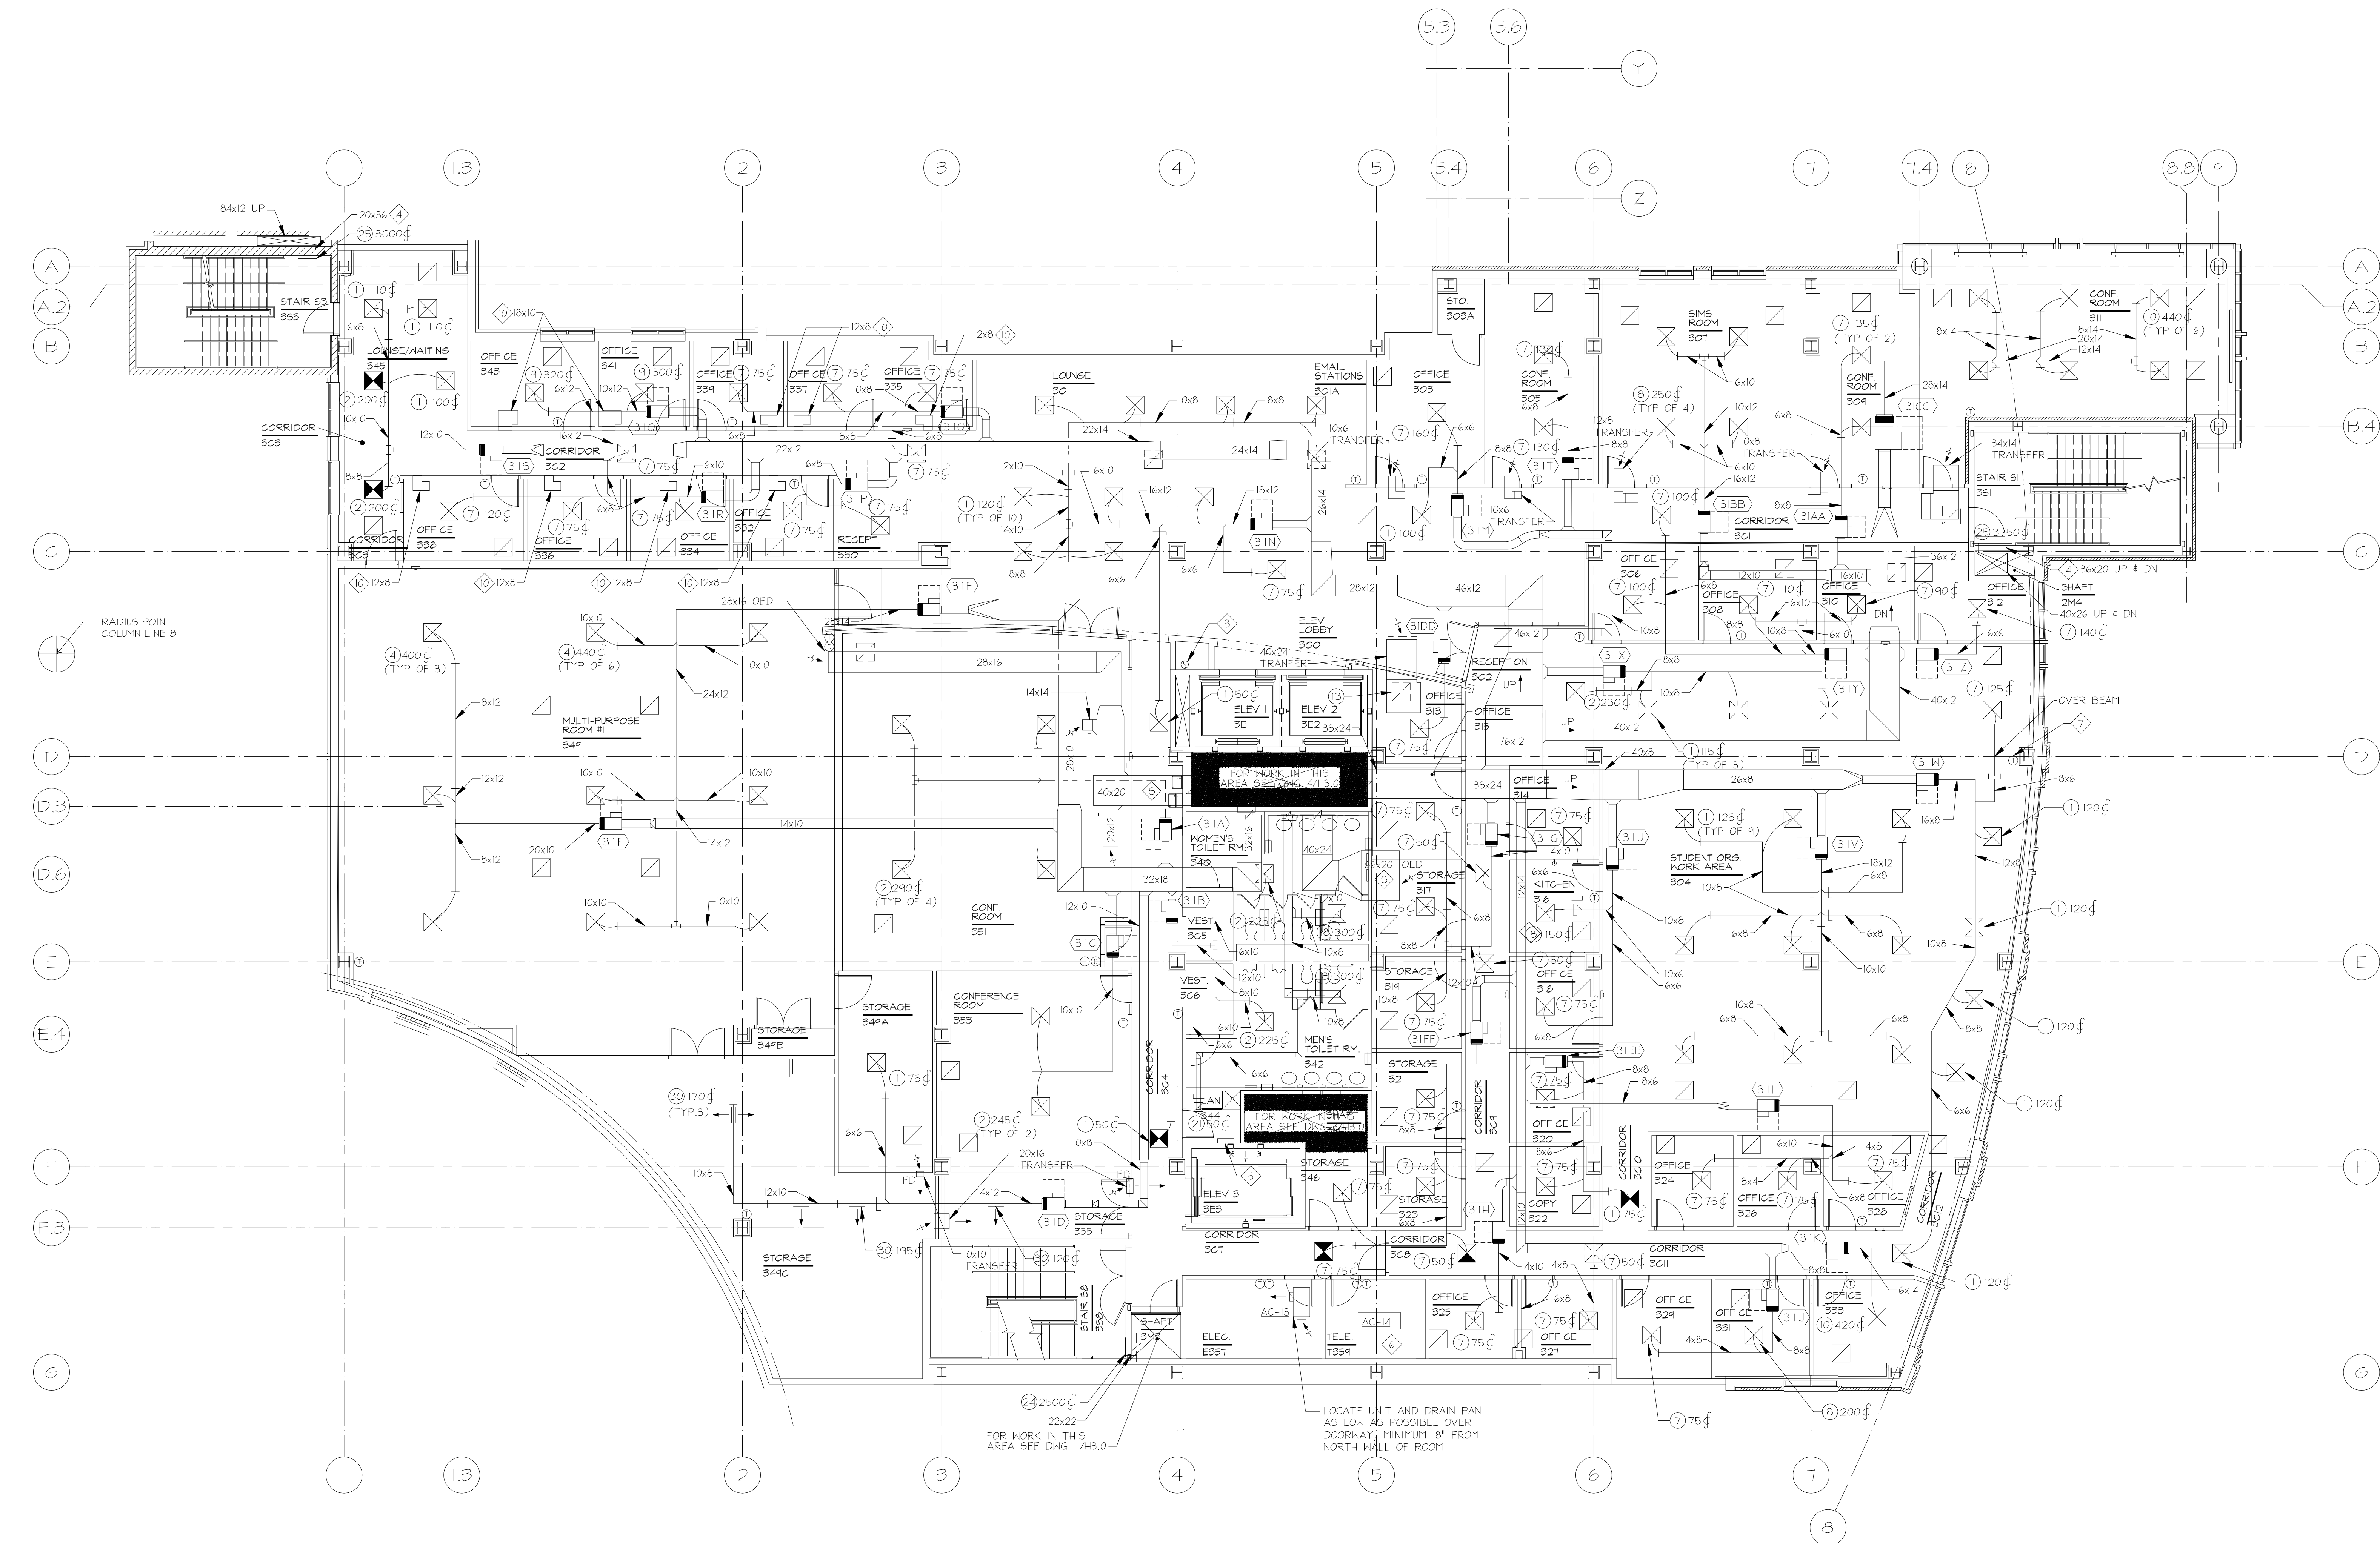

1 DUCTWORK - THIRD FLOOR
1/8"=1'-0"

DRAWING NOTES:

- ALL OPEN END DUCTS SHALL BE PROVIDED WITH BELLMOUTH PER DETAIL.
- ALL TRANSFER DUCTS SHALL BE LINED WITH 1" S.L.

SPECIAL NOTES:

- NOT USED.
- NOT USED.
- 10" Ø OD TYPE L FLUE VENT UP 4 DN. COORD LOCATION WITH PLUMBING RISERS IN SHAFT.
- LOCATE AS HIGH AS POSSIBLE.
- ATC PANEL.
- SEE DWG. H3.5 FOR DUCTWORK.
- CONTROL UNITS 31W AND 31V IN PARALLEL.
- NOT USED.
- NOT USED.
- NOT USED.
- TRANSFER DUCT MOUNTED HIGH, WITH 1" SOUND LINING.



TIMBER COURT
127 ANDERSON STREET
PITTSBURGH, PA 15212-6801
(412) 321-3550
(412) 321-2431 FAX

ASSOCIATE ARCHITECT:



WBCM, - Architects
Whitney Bailey Cox &
Magnani, LLC -
Consulting Engineers
849 Fairmount Ave. Suite 100
Baltimore, MD 21286 (410) 512-4500

Henry Adams, LLC.
Consulting Engineers



600 Baltimore Avenue
Baltimore, MD 21204-4079
410.296.6500
Fax 410.296.3156

Mullins
Engineering Co.

1227 ANAPOLIS ROAD
ODDINGTON, MD 21113
410-519-0800
FAX 410-672-3971
MEC PROJECT NO. 0512300

20	1/29/10	RECORD DRAWING
19	8/14/09	BULLETIN #101
18	4/29/09	BULLETIN #100
17	4/30/09	BULLETIN #099
16	3/30/09	BULLETIN #105
15	4/15/09	BULLETIN #095
14	3/2/09	BULLETIN #94
13	12/16/08	BULLETIN #92
12	12/7/08	BULLETIN #90
11	11/20/08	BULLETIN #79
10	11/19/08	BULLETIN #72 (rev)
9	10/20/08	BULLETIN #69
8	9/4/08	BULLETIN #63
7	7/28/08	BULLETIN #55
6	6/23/08	BULLETIN #51
5	05/23/08	COORD. DWGS RFI 163
4	05/09/08	BULLETIN #31
3	04/14/08	CB-39
2	03/10/08	CBM-2
1	02/18/08	CBM-1
0	05/02/07	For Construction
Rev.	Date:	Comment:

Issued: May 2, 2007

Campus Center


621 West Lombard Street
University of Maryland,
Baltimore
Baltimore, MD

Ductwork Lower Pool Level

100% CONSTRUCTION
DOCUMENTS

UMB PROJECT NO. 99-311
WTV PROJECT NO. 70-4091
© WTV ARCHITECTS \$(edit)\$(REV)\$(yyyy)

H1.3A

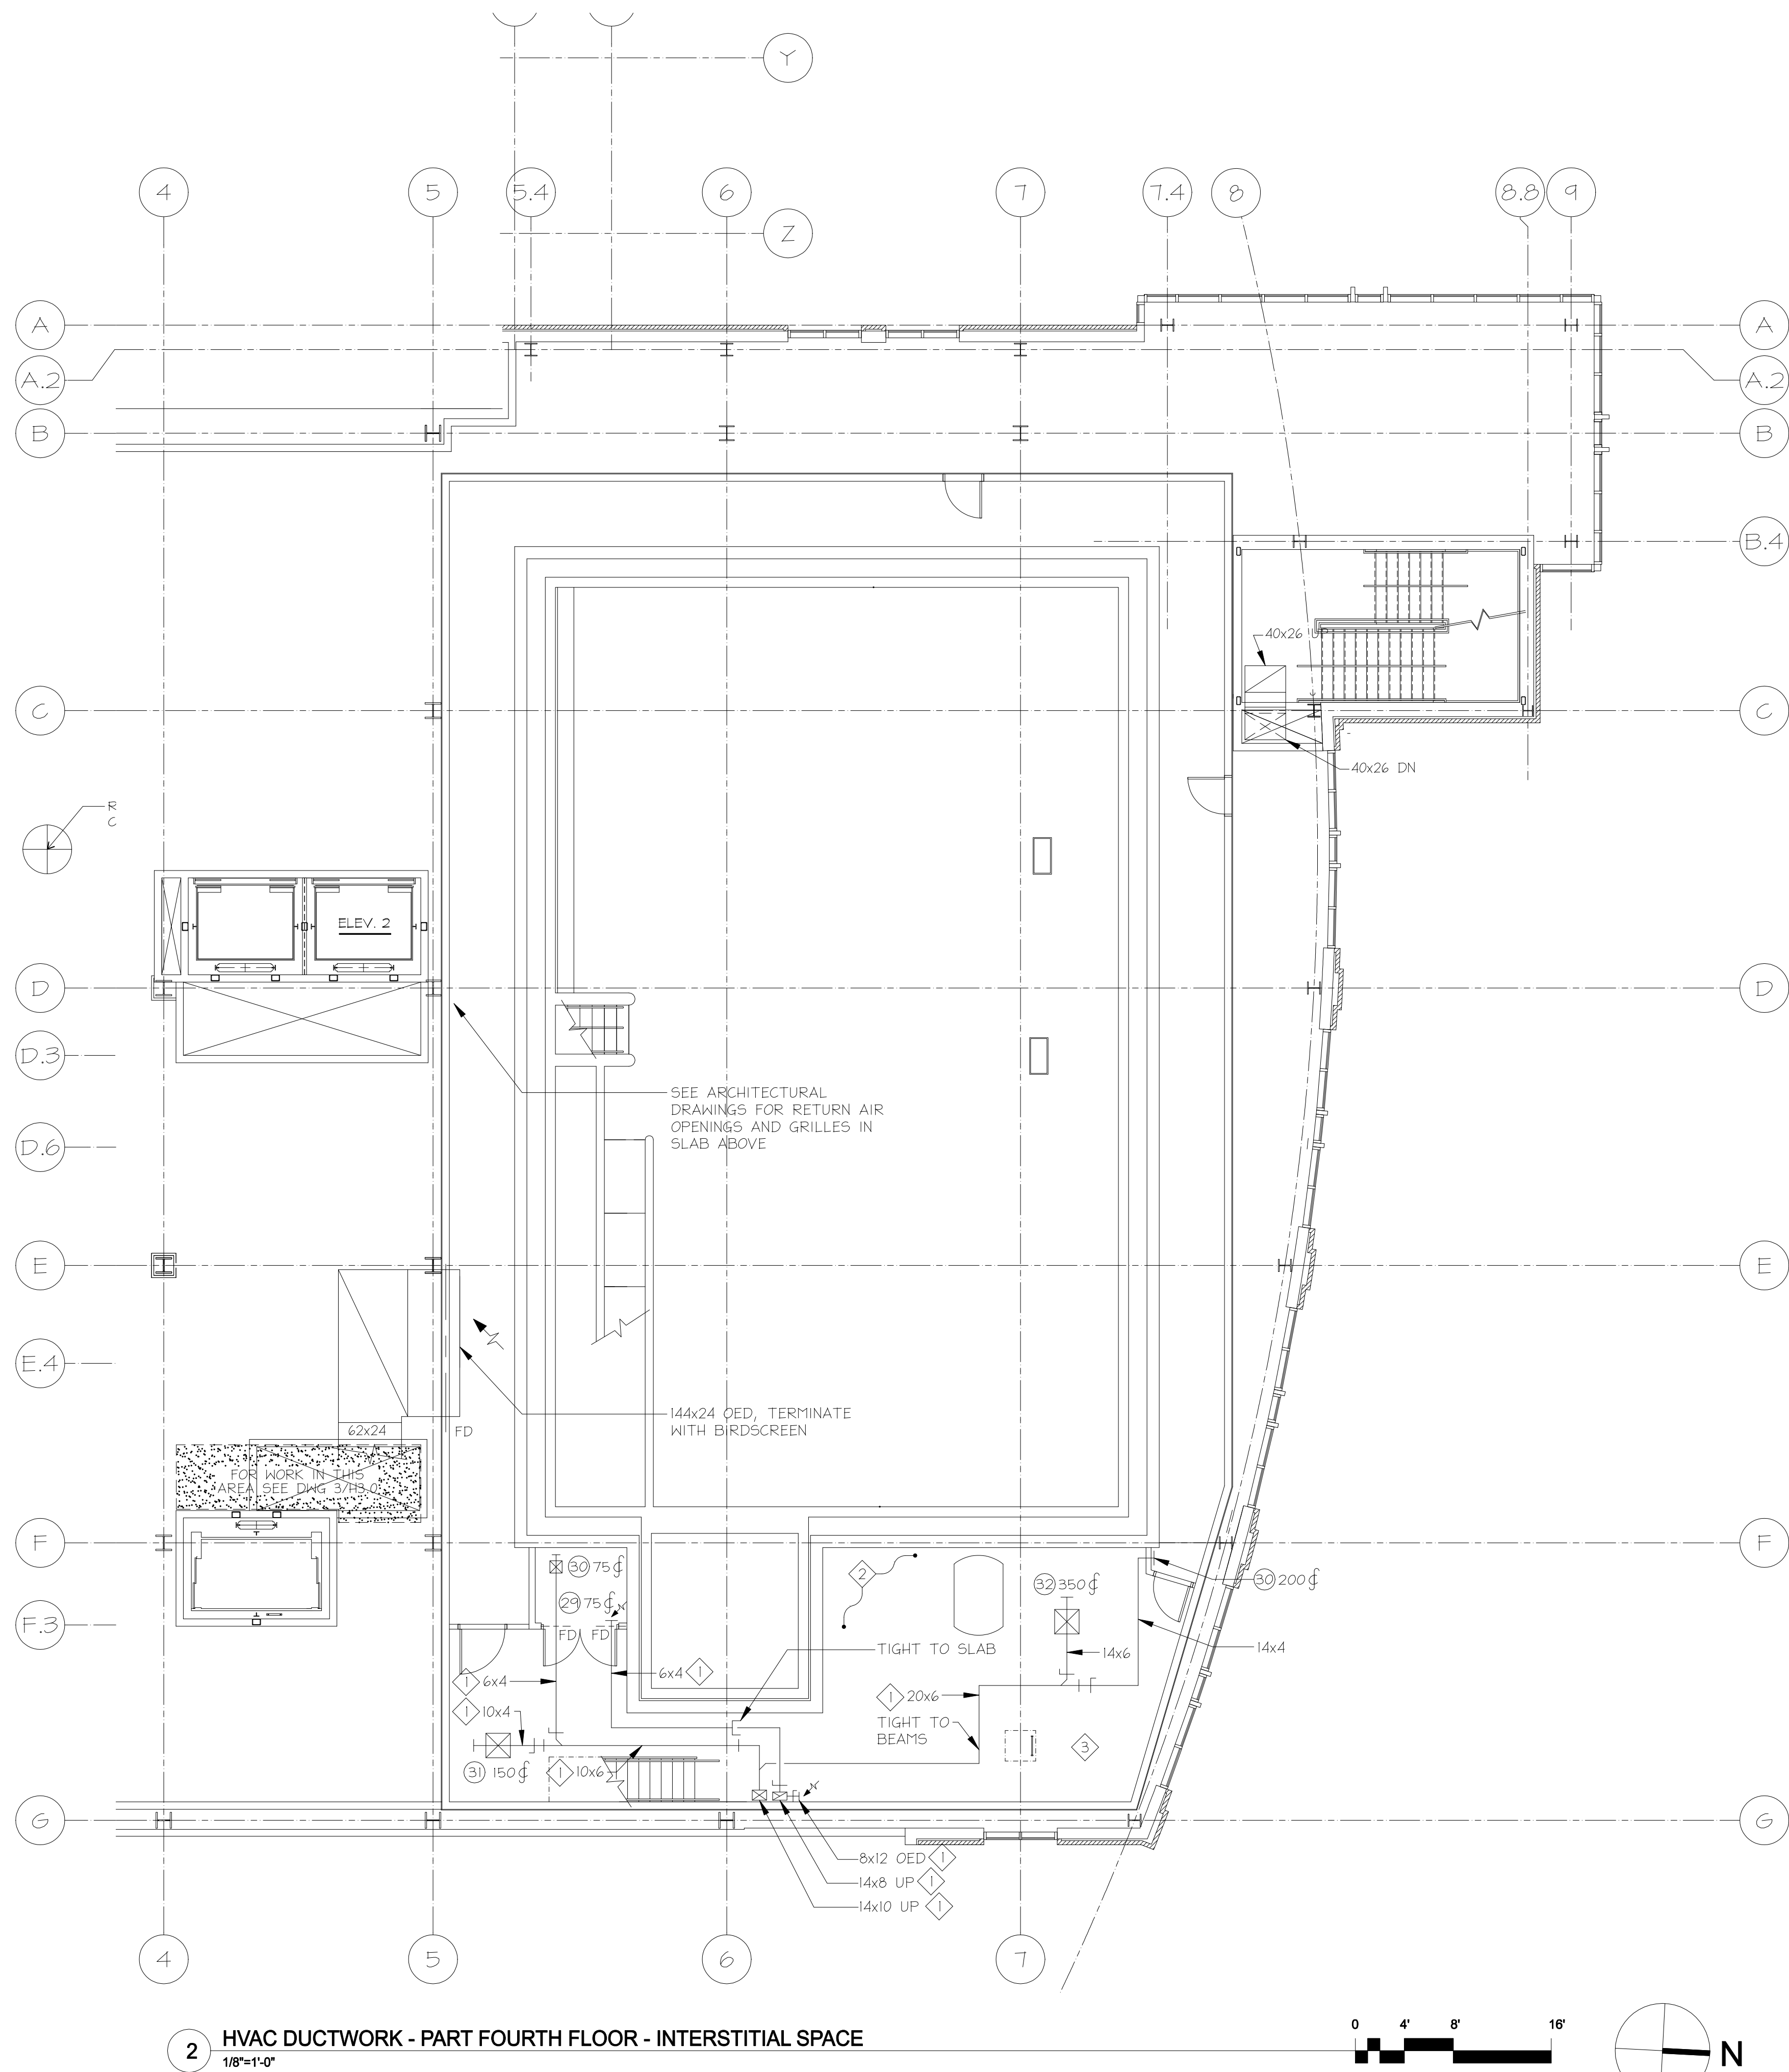

2 HVAC DUCTWORK - PART FOURTH FLOOR - INTERSTITIAL SPACE
1/8"=1'-0"

DRAWING NOTES:

- ALL OPEN END DUCTS SHALL BE PROVIDED WITH BELLMOUTH PER DETAIL.

SPECIAL NOTES:

- ALUMINUM DUCTWORK.
- DUCT INSULATION NOT REQUIRED IN THIS SPACE.
- ALL AIR DEVICES AT THIS LEVEL SHALL BE ALUMINUM CONSTRUCTION.

RECORD DRAWING: This record drawing has been prepared based upon information provided by others. While this information is believed to be reliable, the Design Professional has not verified its accuracy, and thus is not responsible for the accuracy or completeness of this record drawing or for any errors or omissions which may have been incorporated into it as a result of erroneous information provided by others. Those relying on this record document are advised to obtain independent verification of its accuracy before applying it for any purpose.

IF THIS DRAWING DOES NOT MEASURE EXACTLY 36" X 42", IT HAS BEEN REDUCED OR ENLARGED. PLEASE DO NOT SCALE THIS DRAWING.



TIMBER COURT
127 ANDERSON STREET
PITTSBURGH, PA 15212-5801
(412) 321-5555
(412) 321-4331 FAX

ASSOCIATE ARCHITECT:



WBCM, - Architects
Whitney Bailey Cox &
Magnani, LLC
Consulting Engineers
849 Fairmount Ave. Suite 100
Baltimore, MD 21286 (410) 512-4500

Henry Adams, LLC.
Consulting Engineers



600 Baltimore Avenue
Baltimore, MD 21204-4079
410.296.6500
Fax 410.296.3156

Mullins
Engineering Co.

1221 ANNAPOLIS ROAD
DUNELAND, MD 21113
410-519-0890
FAX 410-519-3971
MEC PROJECT NO. 0512300

20	1/29/10	RECORD DRAWING
19	8/4/09	BULLETIN #103
18	4/29/09	BULLETIN #104
17	4/20/09	BULLETIN #105
16	3/30/09	BULLETIN #106
15	4/15/09	BULLETIN #107
14	3/2/09	BULLETIN #108
13	12/16/08	BULLETIN #109
12	12/7/08	BULLETIN #110
11	11/20/08	BULLETIN #111
10	11/19/08	BULLETIN #112 (rev)
9	10/20/08	BULLETIN #113
8	9/4/08	BULLETIN #114
7	7/28/08	BULLETIN #115
6	6/23/08	BULLETIN #116
5	05/23/08	COORD. DWGS RFI 103
4	05/09/08	BULLETIN #117
3	04/14/08	CBM-39
2	03/10/08	CBM-2
1	02/18/08	CBM-1
0	05/02/07	For Construction
Rev.	Date:	Comment:

Issued: May 2, 2007

Campus Center

621 West Lombard Street
University of Maryland,
Baltimore
Baltimore, MD


Ductwork Fourth Floor

100% CONSTRUCTION
DOCUMENTS

UMB PROJECT NO. 99-311
WTW PROJECT NO. 70-4091
© WTW ARCHITECTS S(edin)RE(ig) yyyy)

H1.4

IF THIS DRAWING DOES NOT MEASURE EXACTLY 36" X 42", IT HAS BEEN REDUCED OR ENLARGED. PLEASE DO NOT SCALE THIS DRAWING.

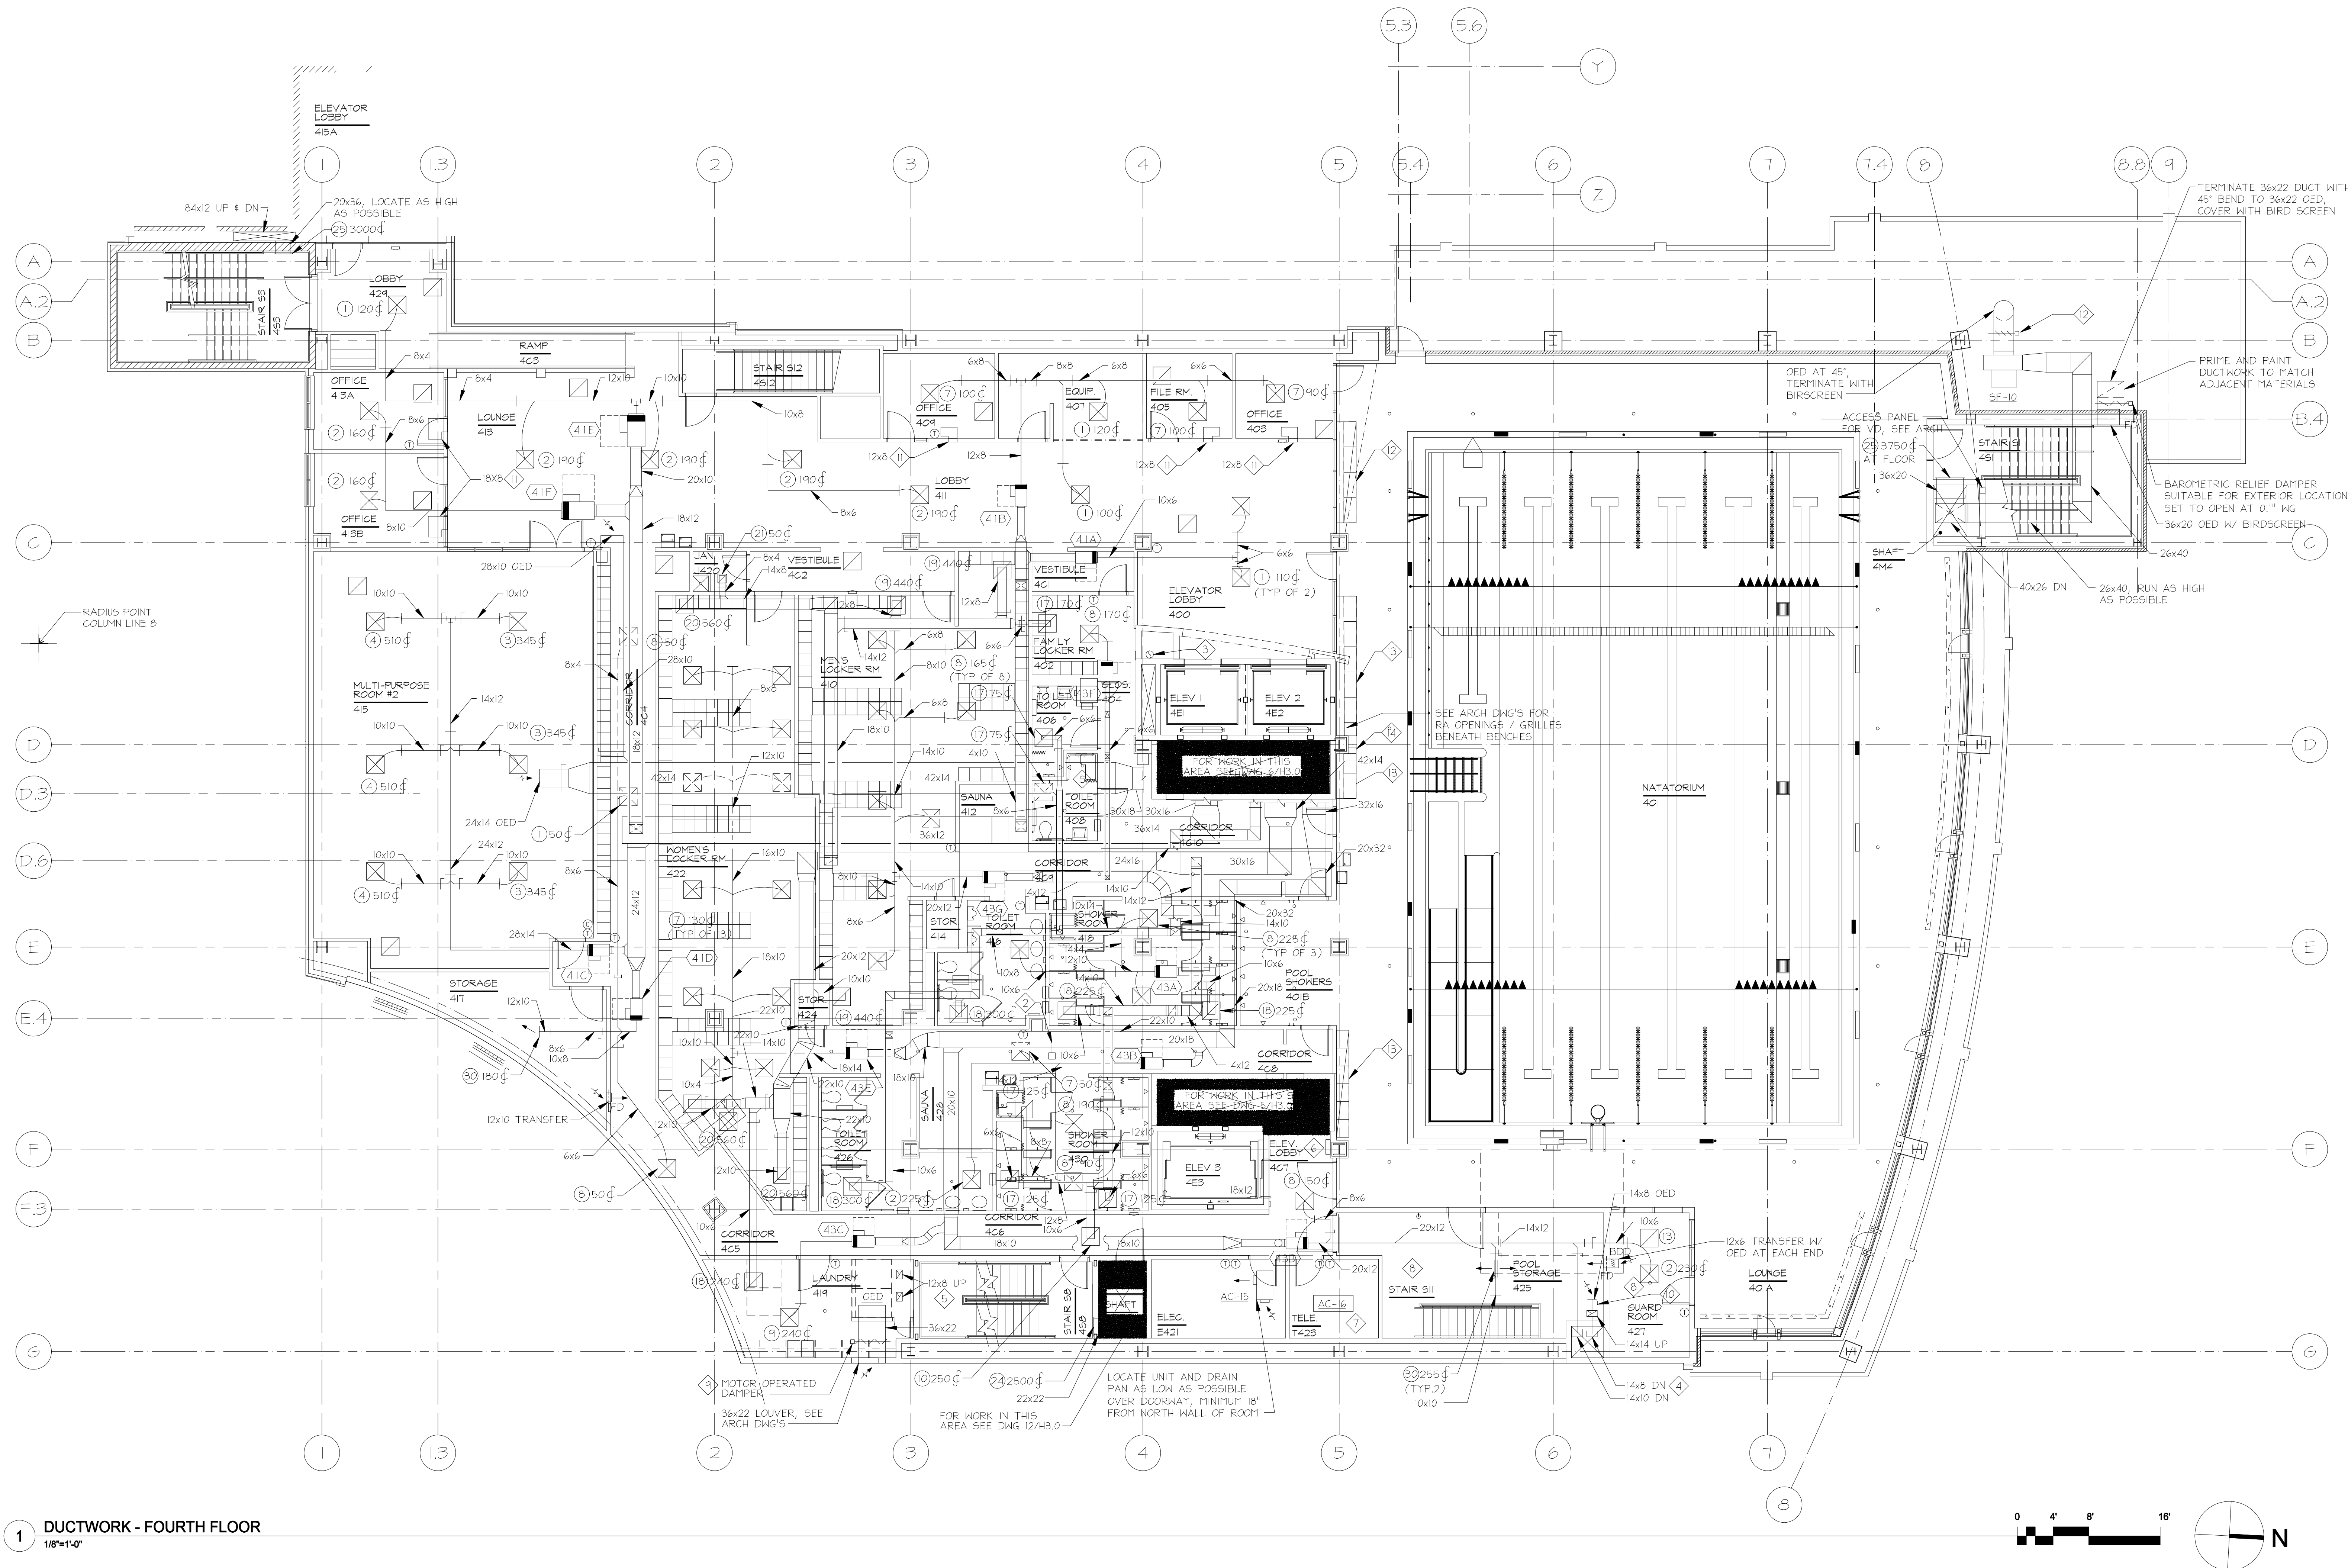

DRAWING NOTES:

1. ALL OPEN END DUCTS SHALL BE PROVIDED WITH BELLMOUTH PER DETAIL.

SPECIAL NOTES:

1. NOT USED.
2. NOT USED.
3. 10" Ø OD TYPE L FLUE VENT UP & DN. COORD LOCATION WITH PLUMBING RISERS IN SHAFT.
4. ALUMINUM DUCTWORK.
5. TRANSITION DOWN TO DRYER EXHAUST CONNECTION (DRYERS PROVIDED BY OWNER).
6. ATC PANEL
7. SEE DWG. H3.5 FOR DETAILED LAYOUT.
8. ALL AIR DEVICES AND DUCTWORK IN THIS ROOM SHALL BE ALUMINUM CONSTRUCTION.
9. INTERLOCK WITH DRYERS SUCH THAT DAMPER OPENS WHENEVER ANY DRYER IS TURNED ON.
10. BALANCE FOR 810 CFM.
11. TRANSFER AIR DUCT MOUNTED HIGH, WITH 1" SOUND LINING.
12. LOW-LEAKAGE PARALLEL BLADE DAMPER WITH 24 VDC ACTUATOR, FOR CONNECTION TO AND CONTROL BY FIRE ALARM SYSTEM. DAMPER AND ACTUATOR SHALL BE SUITABLE FOR EXTERIOR INSTALLATION. DAMPER SHALL BE INTERLOCKED WITH FAN SUCH THAT WHEN IT IS OPERATING, DAMPER IS OPEN.
13. PROVIDE RUSKIN MODEL 1BD2 OR EQUAL FIRE DAMPER IN FLOOR OPENING UNDER BENCH. DAMPER SHALL BE 15" HR RATED, STYLE A TYPE, MANUFACTURED IN ACCORDANCE WITH UL555 WITH STAINLESS STEEL MATERIALS. FUSIBLE LINK SHALL BE 165°F SETPOINT.
14. BLANK OFF FLOOR OPENING UNDER BENCH AT BEAM, TO MEET 2-HOUR RATING OF FLOOR.

RECORD DRAWING: This record drawing has been prepared based upon information provided by others. While this information is believed to be reliable, the Design Professional has not verified its accuracy, and thus is not responsible for the accuracy or completeness of this record drawing or for any errors or omissions which may have been incorporated into it as a result of erroneous information provided by others. Those relying on this record document are advised to obtain independent verification of its accuracy before applying it for any purpose.



TIMBER COURT
127 ANDERSON STREET
PITTSBURGH, PA 15212-6801
(412) 321-5555
(412) 321-3431 FAX

ASSOCIATE ARCHITECT:



WBCM, - Architects
Whitney Bailey Cox &
Magnani, LLC -
Consulting Engineers
849 Fairmount Ave. Suite 100
Baltimore, MD 21286 (410) 512-4500

Henry Adams, LLC.
Consulting Engineers



600 Baltimore Avenue
Baltimore, MD 21204-4079
410.296.6500
Fax 410.296.3156

Mullins
Engineering Co.
1227 ANAPOLIS ROAD
ODDINGTON, MD 21113
410-519-6890
FAX 410-672-3971

MEC PROJECT NO. 0512300

20	1/29/10	RECORD DRAWING
19	8/4/09	BULLETIN #101
18	4/29/09	BULLETIN #100
17	4/20/09	BULLETIN #100R
16	3/30/09	BULLETIN #105
15	4/15/09	BULLETIN #095
14	3/2/09	BULLETIN #84
13	12/16/08	BULLETIN #82
12	12/7/08	BULLETIN #80
11	11/20/08	BULLETIN #79
10	11/19/08	BULLETIN #72 (rev)
9	10/20/08	BULLETIN #69
8	9/4/08	BULLETIN #63
7	7/28/08	BULLETIN #55
6	6/22/08	BULLETIN #51
5	05/23/08	COORD. DWGS RFI 163
4	05/09/08	BULLETIN #31
3	04/14/08	CBM-39
2	03/10/08	CBM-2
1	02/18/08	CBM-1
0	05/02/07	For Construction
Rev.	Date:	Comment:

Issued: May 2, 2007

Campus Center

621 West Lombard Street
University of Maryland,
Baltimore
Baltimore, MD

Ductwork Fifth Floor


100% CONSTRUCTION
DOCUMENTS

UMB PROJECT NO. 99-311
WTC PROJECT NO. 70-4091
© WTC ARCHITECTS & (edit) H1.5 (H1.5)


H1.5

RECORD DRAWING: This record drawing has been prepared based upon information provided by others. While this information is believed to be reliable, the Design Professional has not verified its accuracy, and thus is not responsible for the accuracy or completeness of this record drawing or for any errors or omissions which may have been incorporated into it as a result of erroneous information provided by others. Those relying on this record document are advised to obtain independent verification of its accuracy before applying it for any purpose.

IF THIS DRAWING DOES NOT MEASURE EXACTLY 36" X 42", IT HAS BEEN REDUCED OR ENLARGED. PLEASE DO NOT SCALE THIS DRAWING.

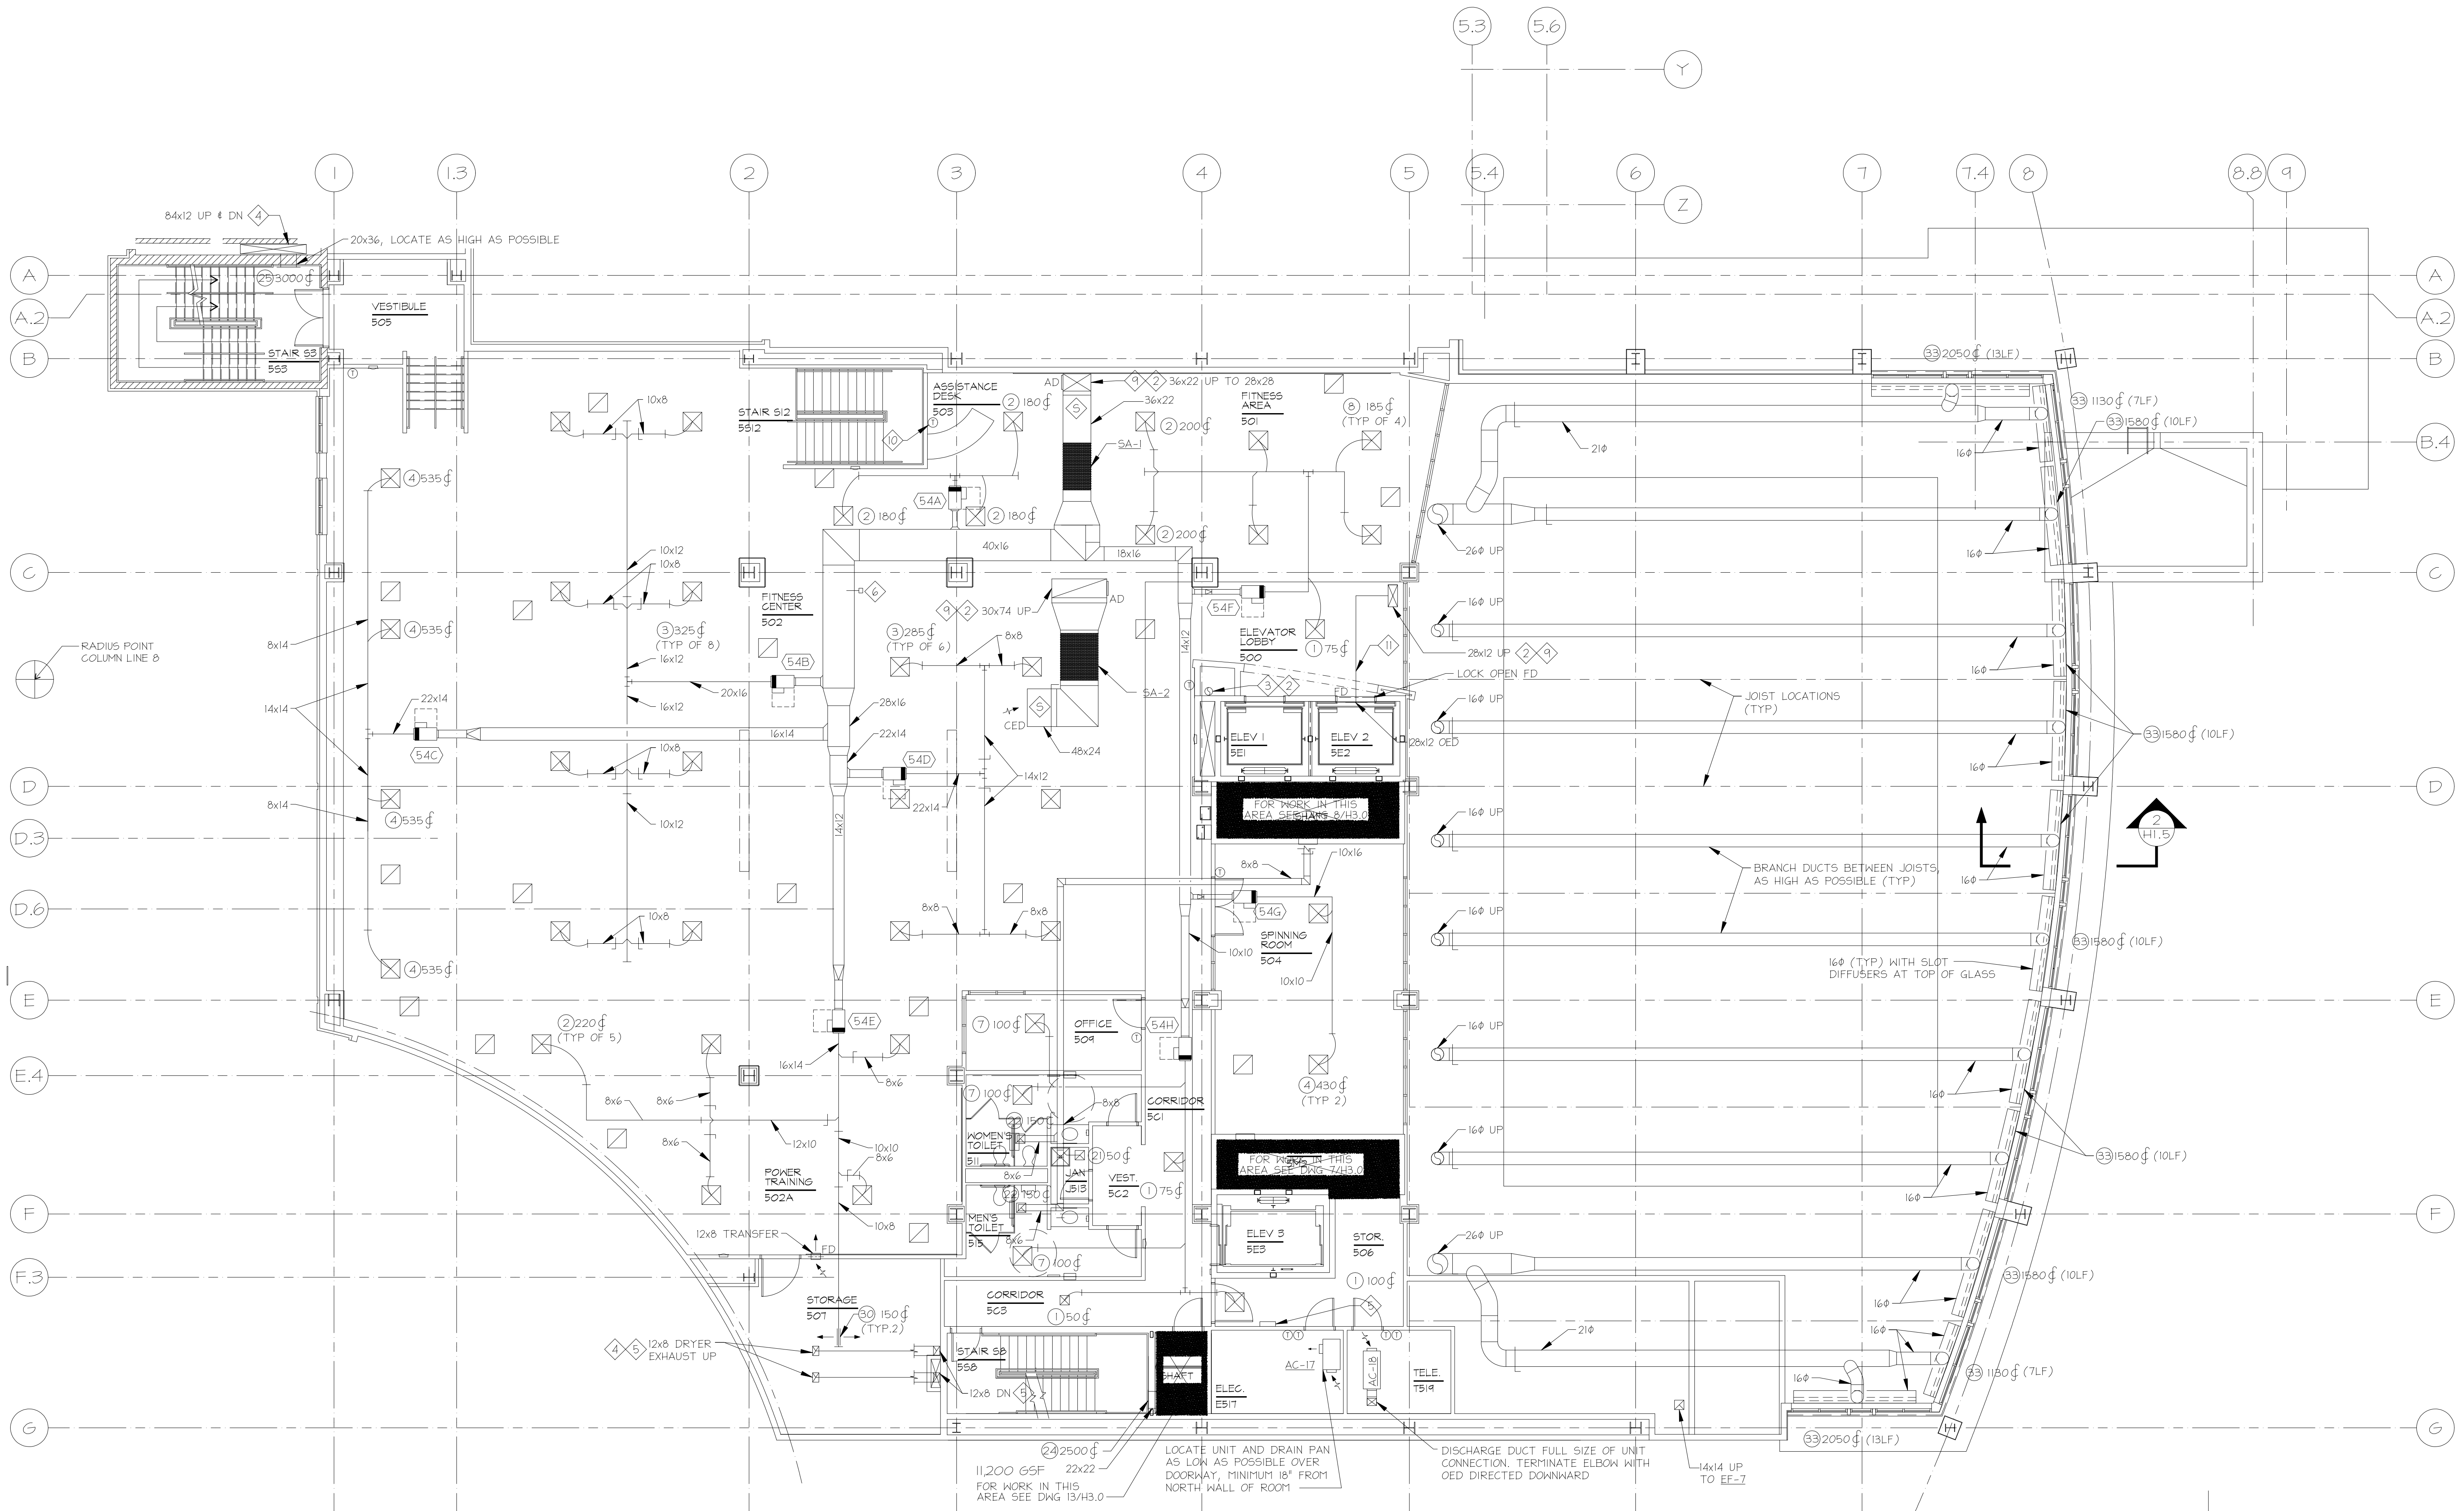

1 DUCTWORK - FIFTH FLOOR
1/8"=1'-0"

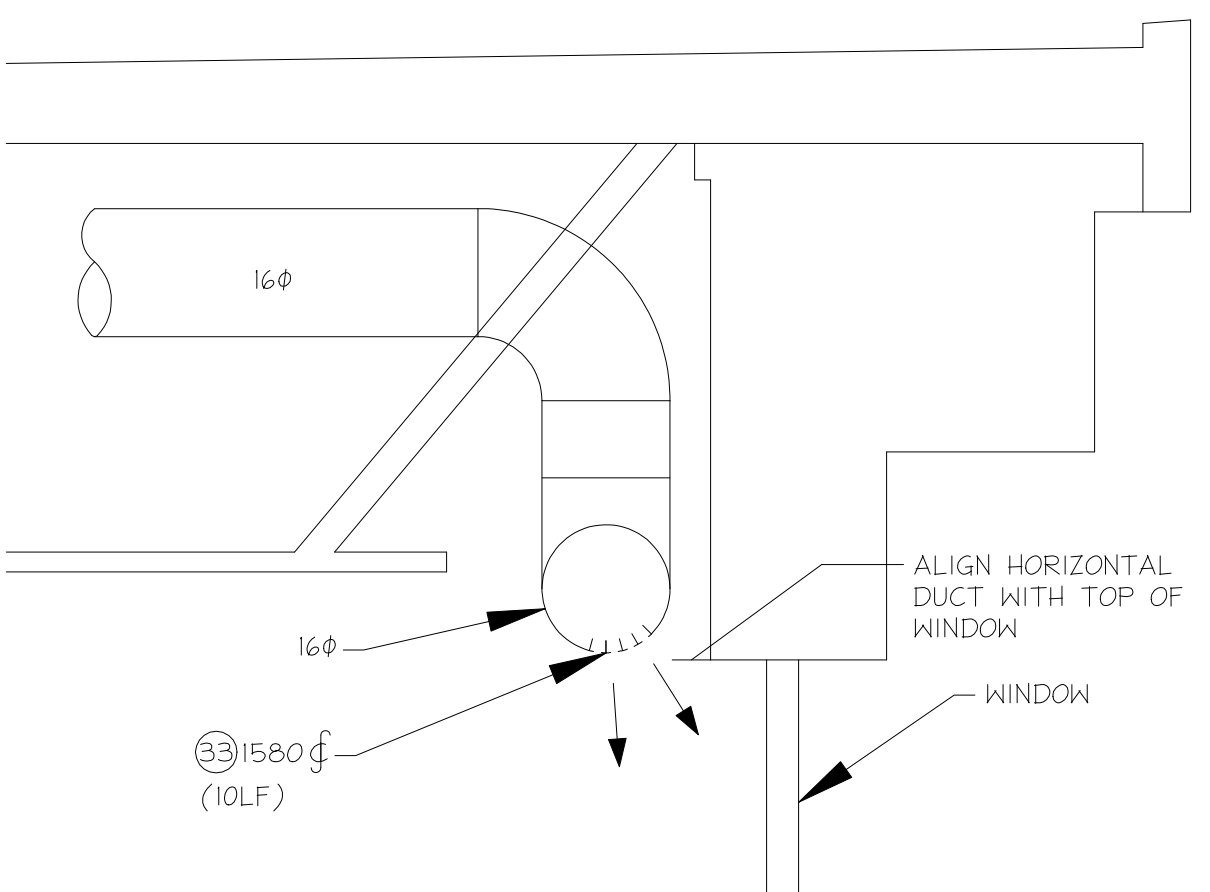

2 SECTION/H1.5
1/2"=1'-0"

DRAWING NOTES:

- ALL OPEN END DUCTS SHALL BE PROVIDED WITH BELLMOUTH PER DETAIL.

SPECIAL NOTES:

- ADJUST THERMOSTAT SET POINT.
- FOR CONTINUATION SEE DRAWING H3.3.
- 10" ØD TYPE L FLUE VENT UP & DN. COORD LOCATION WITH PLUMBING RISERS IN SHAFT.
- FOR CONTINUATION UP, SEE DWG H2.6.
- ELBOWS SHALL BE RADIUS TYPE. PROVIDE ACCESS PANELS FOR LINT CLEANOUT AT EACH ELBOW.
- STATIC PRESSURE SENSOR. SEE ATC SCHEMATICS.
- SEE DWG. H3.5 FOR FURTHER INFORMATION.
- ATC PANEL.
- LOCK OPEN FIRE DAMPER AT SLAB PENETRATION.
- CONTROL UNITS 54D, 54A, 54B, AND 54E IN PARALLEL.
- ENCLOSE DUCTWORK WITH 2-HR RATED INSULATION AS SPECIFIED FOR GREASE EXHAUST DUCTWORK.



TIMBER COURT
127 ANDERSON STREET
PITTSBURGH, PA 15212-5801
(412) 321-3555
(412) 321-3431 FAX

ASSOCIATE ARCHITECT:



WBCM, - Architects
Whitney Bailey Cox &
Magnani, LLC -
Consulting Engineers
849 Fairmount Ave. Suite 100
Baltimore, MD 21286 (410) 512-4500

Henry Adams, LLC.
Consulting Engineers



600 Baltimore Avenue
Baltimore, MD 21204-4079
410.296.6500
Fax 410.296.3156

Mullins
Engineering Co.

1221 ANAPOLIS ROAD
GLENDALE, MD 21113
410-519-0800
FAX 410-519-0971
WEC PROJECT NO. 0512300

20	1/29/10	RECORD DRAWING
19	8/4/09	BULLETIN #101
18	4/29/09	BULLETIN #100
17	4/20/09	BULLETIN #100R
16	3/30/09	BULLETIN #100
15	4/15/09	BULLETIN #99S
14	3/2/09	BULLETIN #94
13	12/16/08	BULLETIN #92
12	12/7/08	BULLETIN #90
11	11/20/08	BULLETIN #79
10	11/19/08	BULLETIN #72 (rev)
9	10/20/08	BULLETIN #69
8	9/4/08	BULLETIN #63
7	7/28/08	BULLETIN #55
6	6/23/08	BULLETIN #51
5	05/23/08	COORD. DWGS RFI 163
4	05/09/08	BULLETIN #31
3	04/14/08	CBM-39
2	03/10/08	CBM-2
1	02/18/08	CBM-1
0	05/02/07	For Construction
Rev.	Date:	Comment:

Issued: May 2, 2007

Campus Center

621 West Lombard Street
University of Maryland,
Baltimore
Baltimore, MD


HVAC Piping Garden Level

100% CONSTRUCTION
DOCUMENTS

UMB PROJECT NO. 99-311
WTW PROJECT NO. 70-4091
© WTW ARCHITECTS & (edit) RE (y/y/y)

H2.0

IF THIS DRAWING DOES NOT MEASURE EXACTLY 36"
X 42", IT HAS BEEN REDUCED OR ENLARGED.
PLEASE DO NOT SCALE THIS DRAWING.

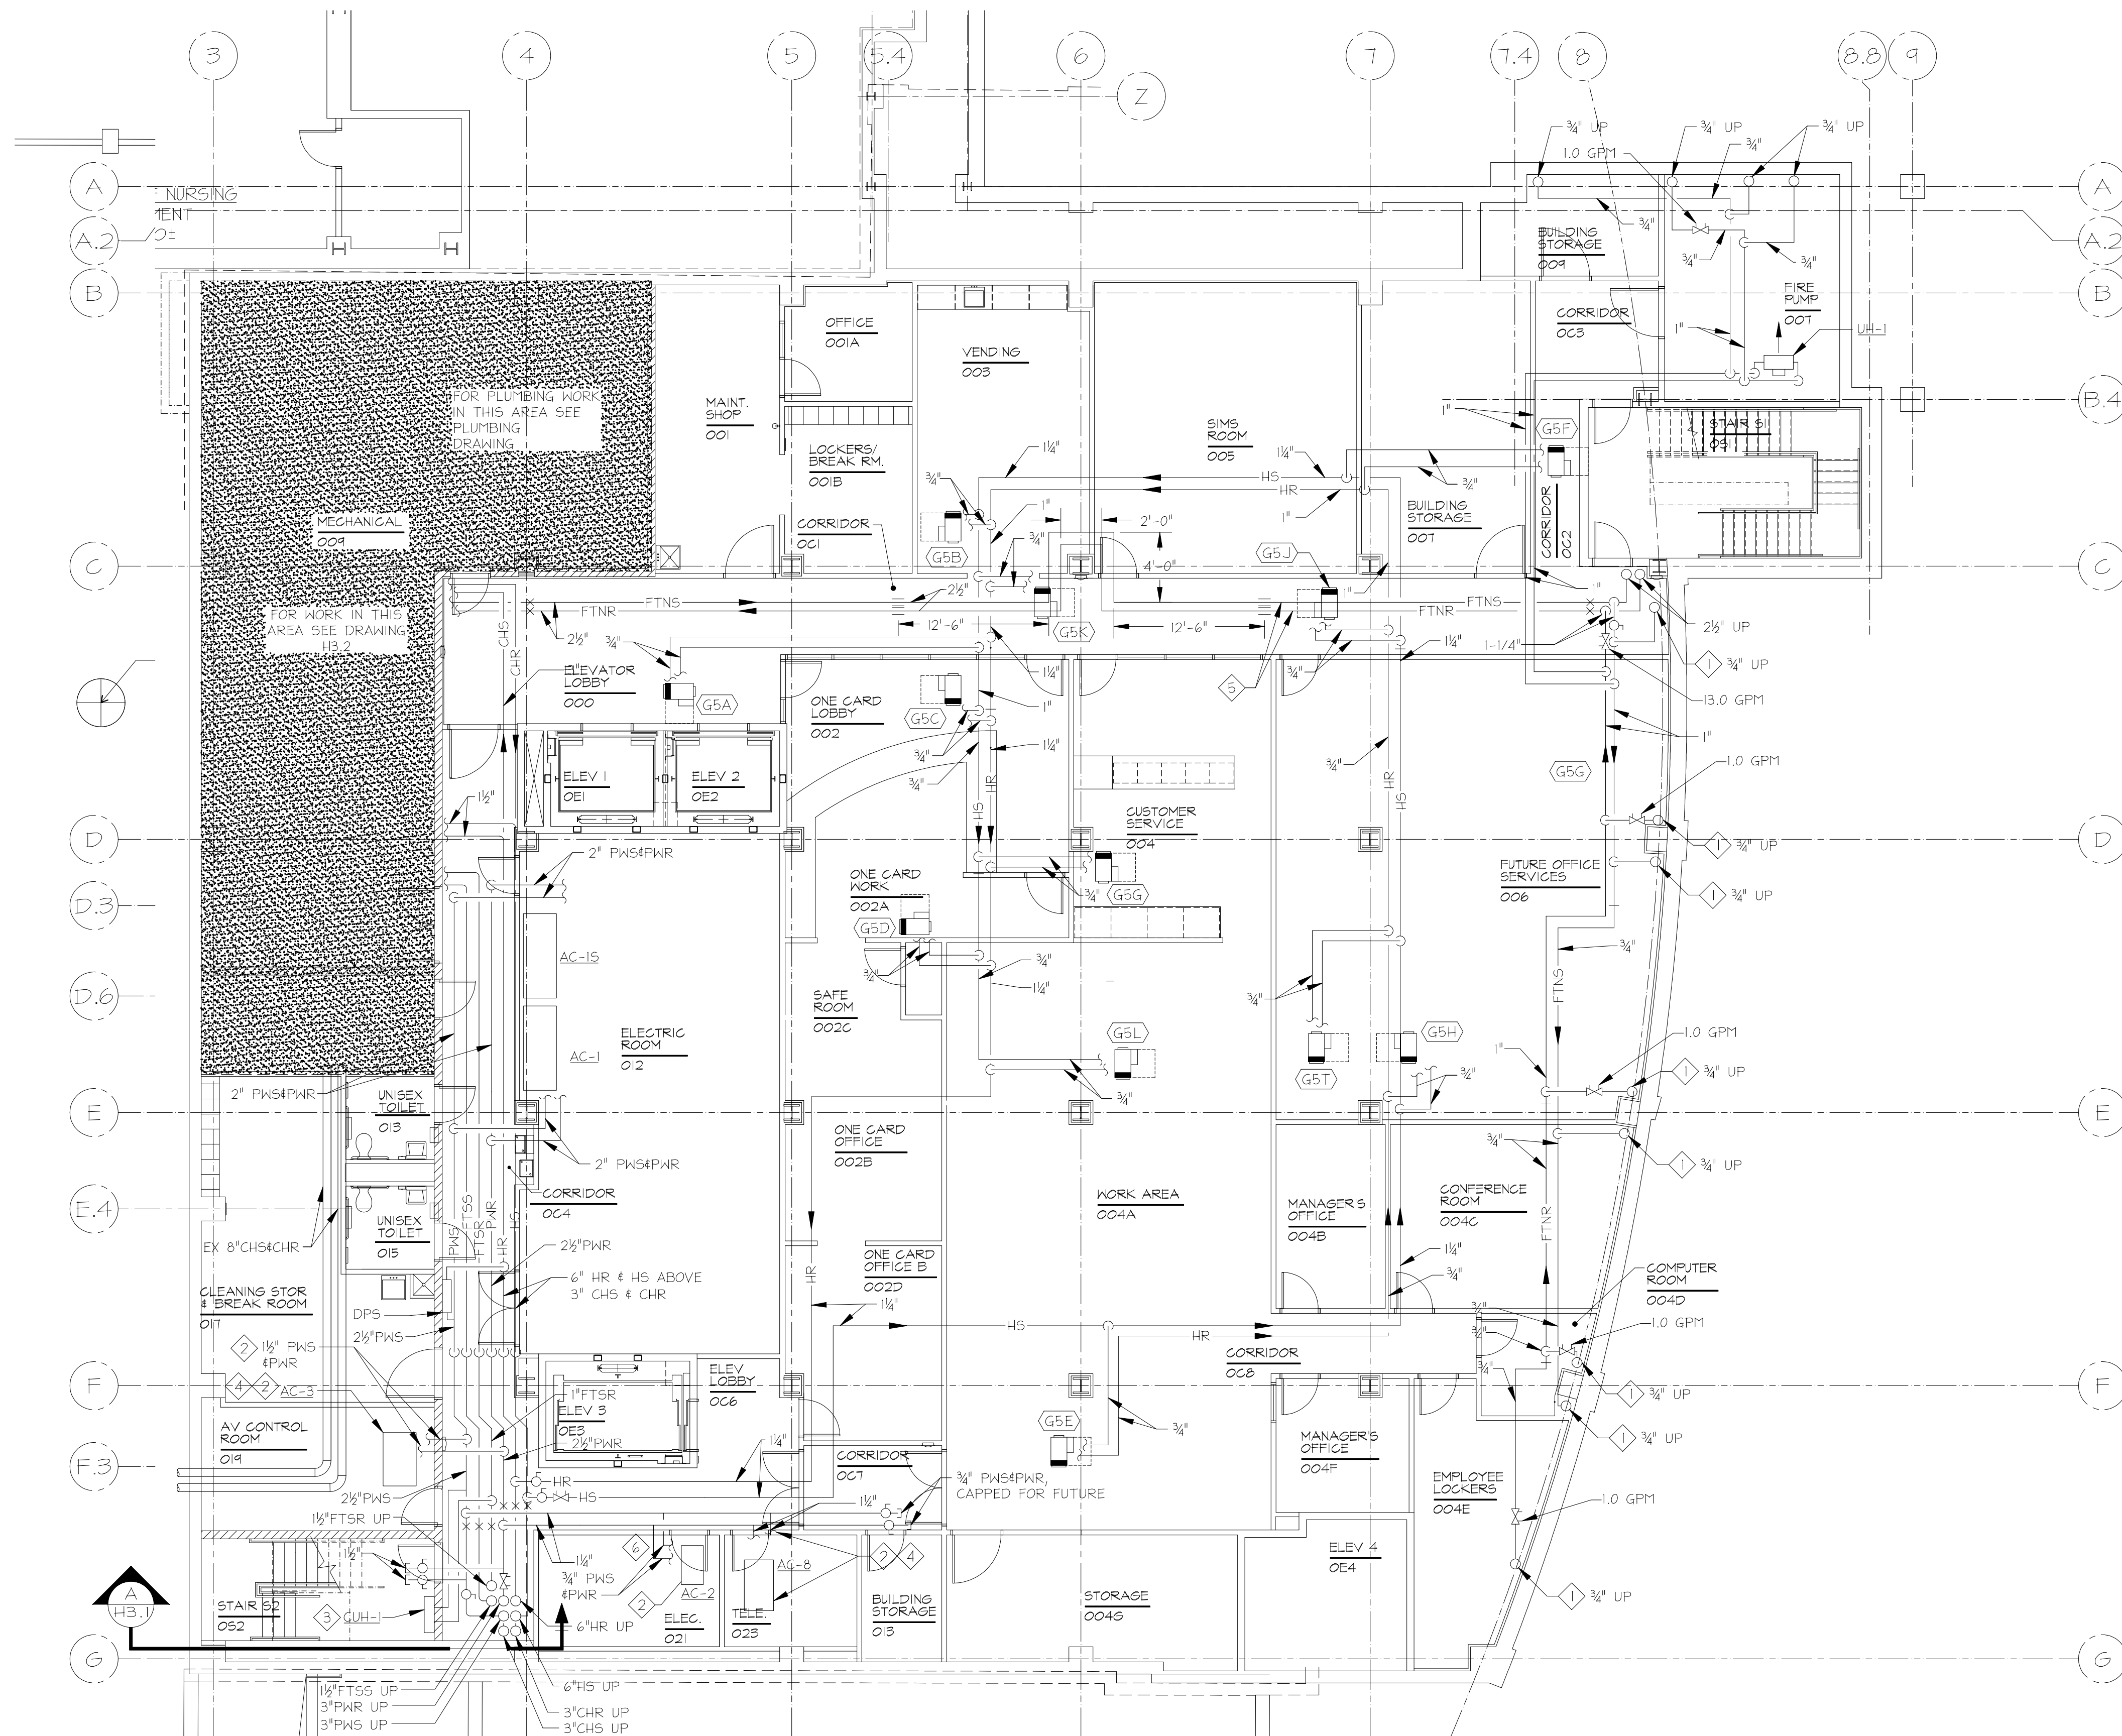

1 HVAC PIPING - GARDEN LEVEL
1/8"=1'-0"



DRAWING NOTES:

- SLAB PENETRATIONS OF FINNED TUBE SYSTEM PIPING SHALL BE BETWEEN BEAM AND WALL.

SPECIAL NOTES:

- FOR CONTINUATION SEE H2-1.
- PROVIDE DRAIN PAN UNDER PIPING AND UNIT.
- ON LANDING, SEE SECTION.
- SEE DWG. H3.5 FOR DETAILED LAYOUT.
- ALL FINNED TUBE PIPING IN ORIGINAL SCOPE OF WORK.
- COORDINATE PIPING TO MAINTAIN CODE CLEARANCES WITHIN ELECTRICAL ROOM.

RECORD DRAWING: This record drawing has been prepared based upon information provided by others. While this information is believed to be reliable, the Design Professional has not verified its accuracy, and thus is not responsible for the accuracy or completeness of this record drawing or for any errors or omissions which may have been incorporated into it as a result of erroneous information provided by others. Those relying on this record document are advised to obtain independent verification of its accuracy before applying it for any purpose.



TIMBER COURT
127 ANDERSON STREET
PITTSBURGH, PA 15212-5801
(412) 321-5555
(412) 321-3431 FAX

ASSOCIATE ARCHITECT:



WBCM, - Architects
Whitney Bailey Cox &
Magnani, LLC -
Consulting Engineers
849 Fairmount Ave, Suite 100
Baltimore, MD 21286 (410) 512-4500

Henry Adams, LLC.
Consulting Engineers



600 Baltimore Avenue
Baltimore, MD 21204-4079
410.296.6500
Fax 410.296.3156

Mullins
Engineering Co.

1251 ANNAPOLIS ROAD
ODDINGTON, MD 21113
410-519-0800
FAX 410-672-3971
MEC PROJECT NO. 0512300

20	1/29/10	RECORD DRAWING
19	8/4/09	BULLETIN #101
18	4/29/09	BULLETIN #100
17	4/20/09	BULLETIN #100R
16	3/30/09	BULLETIN #105
15	4/15/09	BULLETIN #095
14	3/2/09	BULLETIN #84
13	12/16/08	BULLETIN #82
12	12/7/08	BULLETIN #80
11	11/20/08	BULLETIN #79
10	11/19/08	BULLETIN #72 (rev)
9	10/20/08	BULLETIN #69
8	9/4/08	BULLETIN #63
7	7/28/08	BULLETIN #55
6	6/23/08	BULLETIN #51
5	05/23/08	COORD. DWGS RFI 163
4	05/09/08	BULLETIN #31
3	04/14/08	CBM-39
2	03/10/08	CBM-2
1	02/18/08	CBM-1
0	05/02/07	For Construction
Rev.	Date:	Comment:
Issued: May 2, 2007		

Campus Center

621 West Lombard Street
University of Maryland,
Baltimore
Baltimore, MD


HVAC Piping First Floor

100% CONSTRUCTION
DOCUMENTS

UMB PROJECT NO. 99-311
WTW PROJECT NO. 70-4091
© WTW ARCHITECTS & (edit/REV/0# yyyy)

H2.1

IF THIS DRAWING DOES NOT MEASURE EXACTLY 36" X 42", IT HAS BEEN REDUCED OR ENLARGED. PLEASE DO NOT SCALE THIS DRAWING.

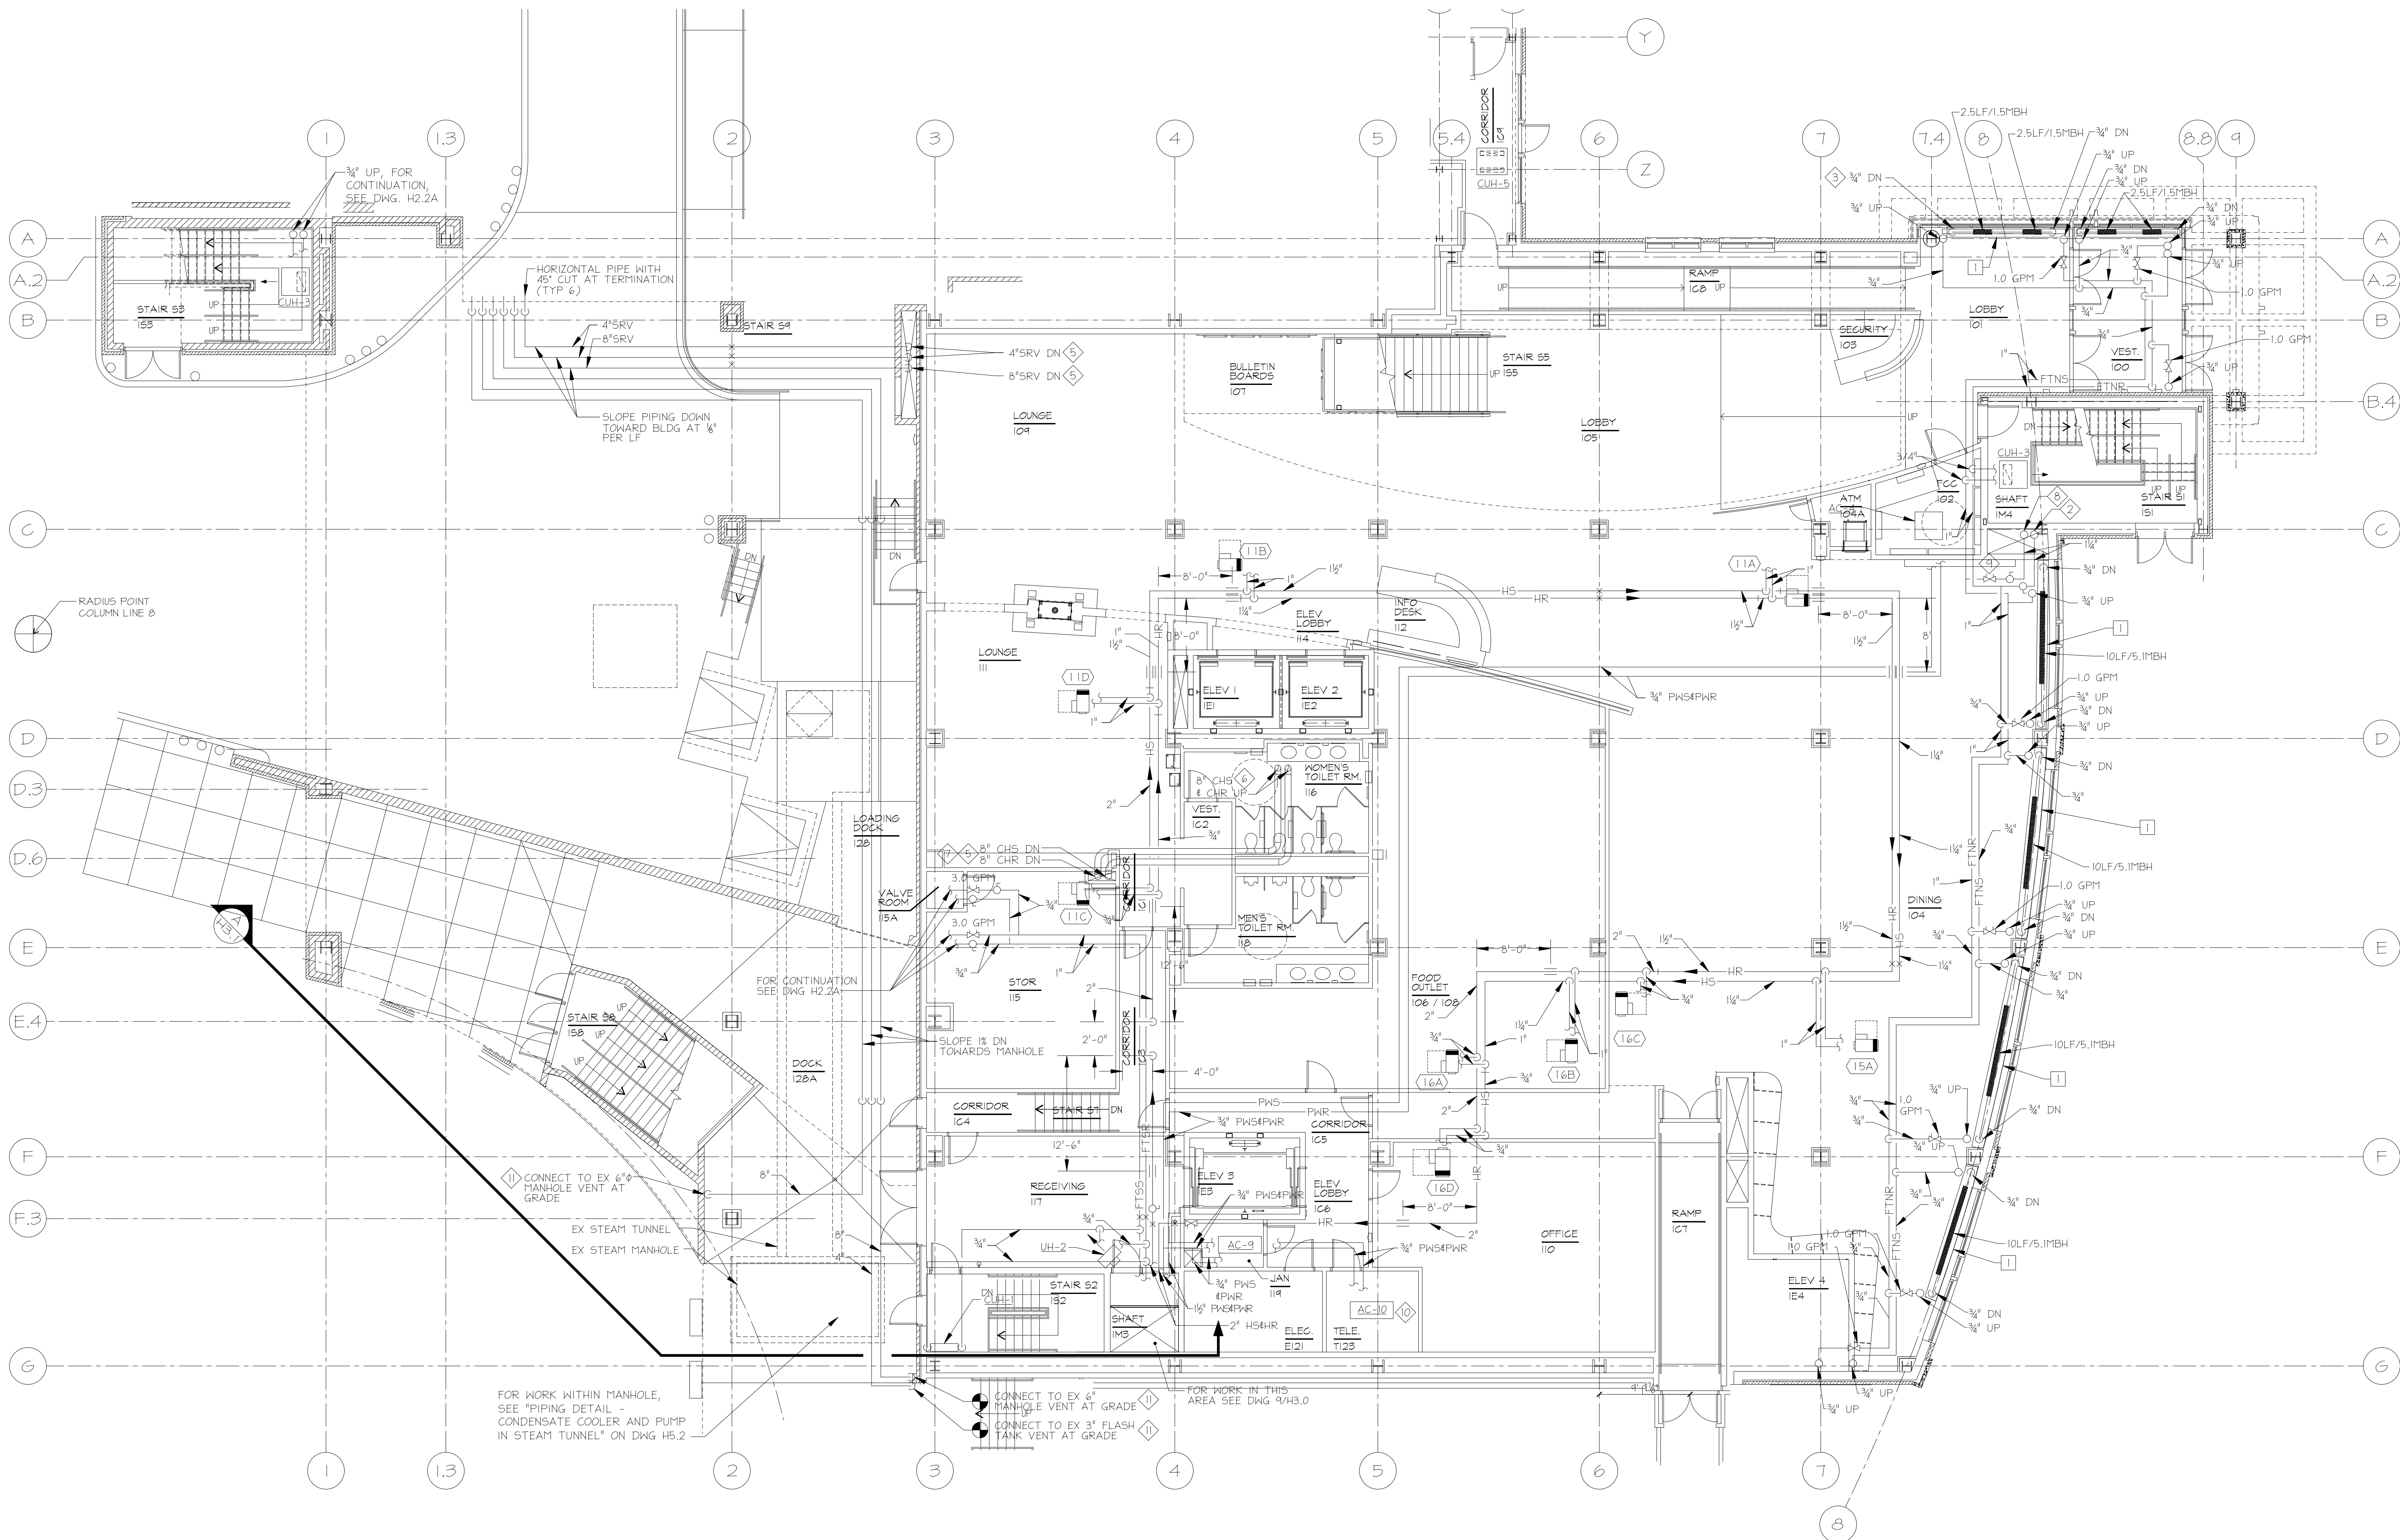

1 HVAC PIPING - FIRST FLOOR 1/8"=1'-0"



DRAWING NOTES:

1. AT EXTERIOR WALLS, SLAB PENETRATIONS OF FINNED TUBE SYSTEM PIPING SHALL BE BETWEEN BEAM AND WALL.

SPECIAL NOTES:

- 1 UP TO SECOND FLOOR, FOR CONTINUATION SEE H2-2.
- 2 2 1/2" FTNR DN, 2" FTNR UP.
- 3 DN TO GROUND FLOOR, FOR CONTINUATION SEE H2-0.
- 4 NOT USED.
- 5 FOR CONTINUATION, SEE DWG. H3.2.
- 6 FOR CONTINUATION, SEE DWG. 2 / H3.0.
- 7 PROVIDE AS PART OF ALT #2.
- 8 2 1/2" FTNS DN, 2" FTNS UP.
- 9 10 GPM.
- 10 SEE DWG. H3.5 FOR DETAILED LAYOUT.
- 11 REMOVE EXISTING GOOSENECK VENT PIPING.

RECORD DRAWING: This record drawing has been prepared based upon information provided by others. While this information is believed to be reliable, the Design Professional has not verified its accuracy, and thus is not responsible for the accuracy or completeness of this record drawing or for any errors or omissions which may have been incorporated into it as a result of erroneous information provided by others. Those relying on this record document are advised to obtain independent verification of its accuracy before applying it for any purpose.



TIMBER COURT
127 ANDERSON STREET
PITTSBURGH, PA 15212-5801
(412) 321-5555
(412) 321-3431 FAX

ASSOCIATE ARCHITECT:



WBCM, - Architects
Whitney Bailey Cox &
Magnani, LLC
Consulting Engineers
849 Fairmount Ave. Suite 100
Baltimore, MD 21286 (410) 512-4500

Henry Adams, LLC.
Consulting Engineers



600 Baltimore Avenue
Baltimore, MD 21204-4079
410.296.6500
Fax 410.296.3156

Mullins
Engineering Co.

1221 ANAPOLIS ROAD
ODDINGTON, MD 21113
410-519-0800
FAX 410-512-3973
MEC PROJECT NO. 0512300

20	1/29/10	RECORD DRAWING
19	8/4/09	BULLETIN #101
18	4/29/09	BULLETIN #100
17	4/20/09	BULLETIN #100R
16	3/30/09	BULLETIN #105
15	4/15/09	BULLETIN #095
14	3/2/09	BULLETIN #84
13	12/16/08	BULLETIN #82
12	12/7/08	BULLETIN #80
11	11/20/08	BULLETIN #79
10	11/19/08	BULLETIN #72 (rev)
9	10/20/08	BULLETIN #69
8	9/4/08	BULLETIN #63
7	7/28/08	BULLETIN #55
6	6/23/08	BULLETIN #51
5	05/23/08	COORD. DWGS RFI 163
4	05/09/08	BULLETIN #31
3	04/14/08	CBM-39
2	03/10/08	CBM-2
1	02/18/08	CBM-1
0	05/02/07	For Construction
Rev.	Date:	Comment:
Issued:	May 2, 2007	

Campus Center

621 West Lombard Street
University of Maryland,
Baltimore
Baltimore, MD


HVAC Piping Second Floor

100% CONSTRUCTION
DOCUMENTS

UMB PROJECT NO. 99-311
WTW PROJECT NO. 70-4091
© WTW ARCHITECTS S(edin)RE(iff) yyy)

H2.2

IF THIS DRAWING DOES NOT MEASURE EXACTLY 36" X 42", IT HAS BEEN REDUCED OR ENLARGED. PLEASE DO NOT SCALE THIS DRAWING.

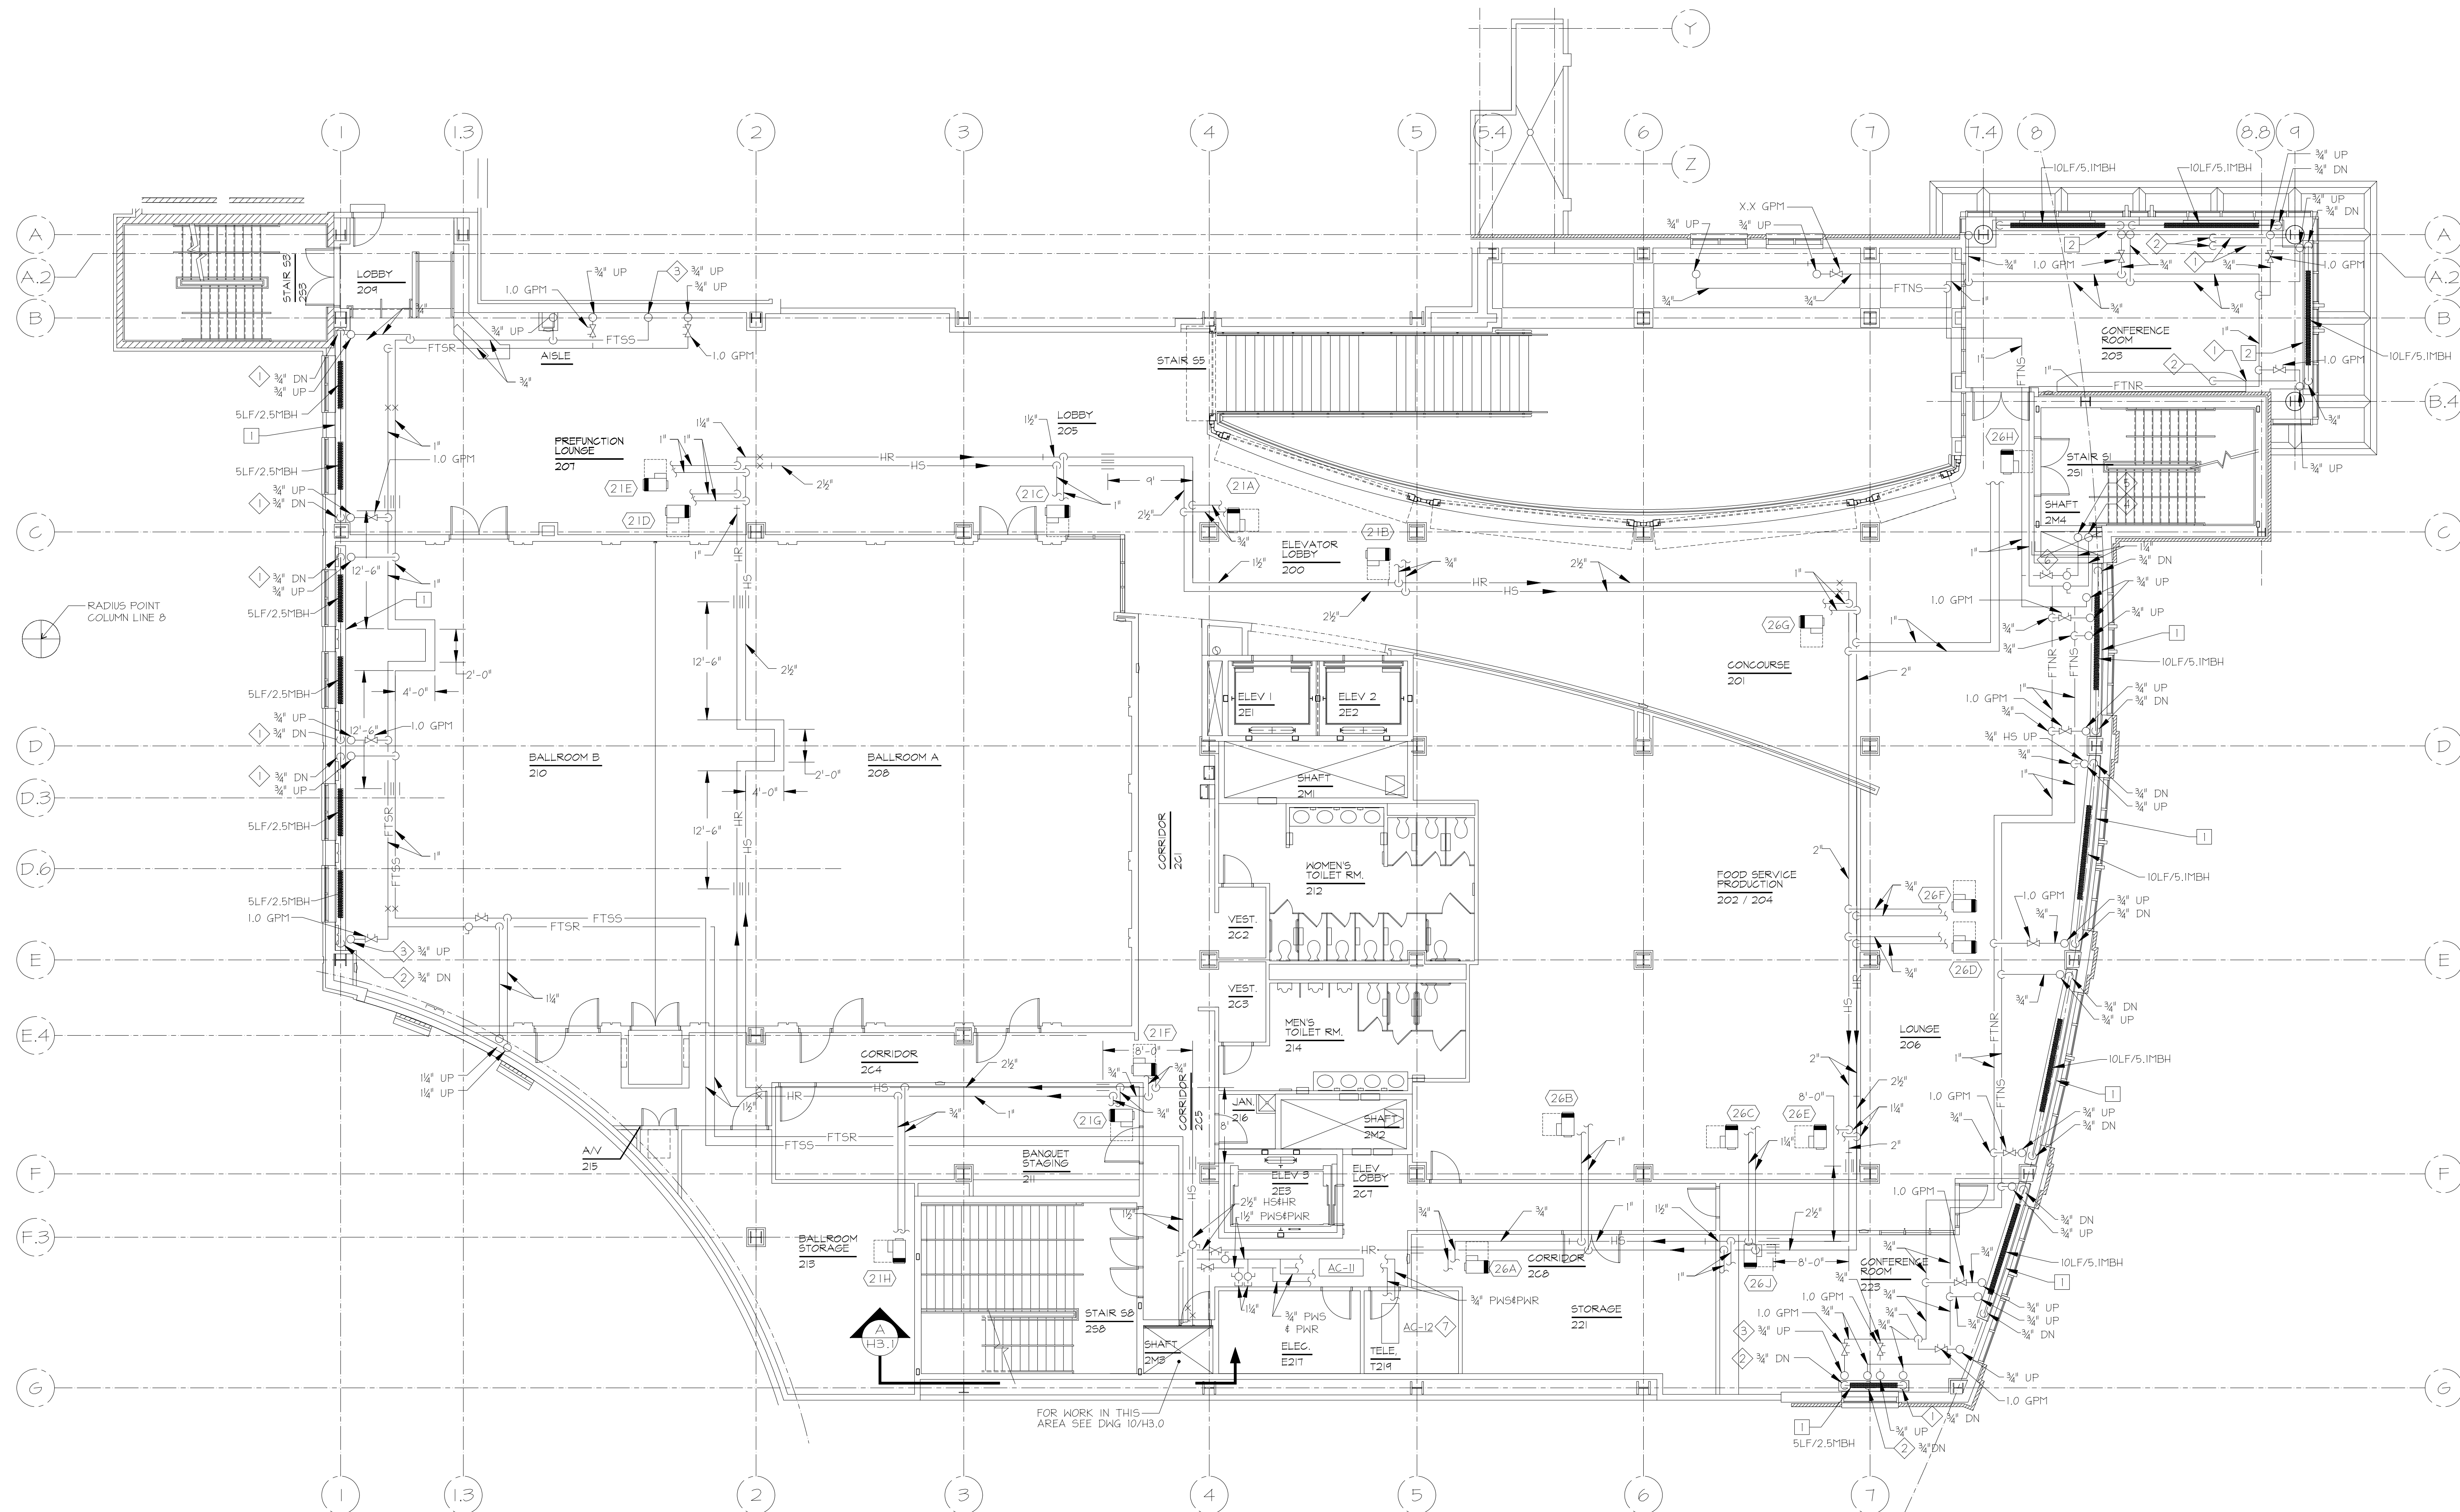

1 HVAC PIPING - SECOND FLOOR
1/8"=1'-0"

DRAWING NOTES:

1. AT EXTERIOR WALLS, SLAB PENETRATIONS OF FINNED TUBE SYSTEM PIPING SHALL BE BETWEEN BEAM AND WALL.

SPECIAL NOTES:

1. FOR CONTINUATION, SEE DWG. H2.2A.
2. DN TO FIRST FLOOR CEILING, FOR CONTINUATION SEE H2-1.
3. H5HR UP TO THIRD FLOOR, FOR CONTINUATION SEE H2-3.
4. 2" FTNR DN, 1/2" FTNR UP.
5. 2" FTNS DN, 1/2" FTNS UP.
6. 11.0 GPM.
7. SEE DWG. H3.5 FOR DETAILED LAYOUT. PROVIDE DRAIN PAN UNDER UNIT 4 PIPING WITHIN THIS ROOM.

RECORD DRAWING: This record drawing has been prepared based upon information provided by others. While this information is believed to be reliable, the Design Professional has not verified its accuracy, and thus is not responsible for the accuracy or completeness of this record drawing or for any errors or omissions which may have been incorporated into it as a result of erroneous information provided by others. Those relying on this record document are advised to obtain independent verification of its accuracy before applying it for any purpose.

20	1/29/2010	RECORD DRAWING
19	8/4/2009	BULLETIN #120
18	4/29/2009	BULLETIN #109
17	4/30/2009	BULLETIN #108R
16	4/30/2009	BULLETIN #105
15	4/15/2009	BULLETIN #99R
14	3/2/2009	BULLETIN #94
13	1/15/2008	BULLETIN #82
12	12/7/08	BULLETIN #80
11	11/20/2008	BULLETIN #78
10	10/19/2008	BULLETIN #72 (rev)
9	10/19/2008	BULLETIN #69
8	9/1/2008	BULLETIN #63
7	7/28/2008	BULLETIN #55
6	6/23/2008	BULLETIN #51
5	05/23/2008	COORD. DWGS RFI 16
4	05/09/2008	BULLETIN #31
3	04/14/2008	CBM-39
2	03/10/2008	CBM-2
1	02/18/2008	CBM-1
0	05/02/07	For Construction
Rev.	Date:	Comment:
Issued: May 2, 2007		

Campus Center

621 West Lombard Street
University of Maryland,
Baltimore
Baltimore, MD


HVAC Piping Third Floor

100% CONSTRUCTION DOCUMENTS

UMB PROJECT NO. 99-311
WTW PROJECT NO. 70-4091
© WTW ARCHITECTS \$(edit)E\0# yyyy

H2.3

IF THIS DRAWING DOES NOT MEASURE EXACTLY 30" X 42", IT HAS BEEN REDUCED OR ENLARGED.
PLEASE DO NOT SCALE THIS DRAWING.

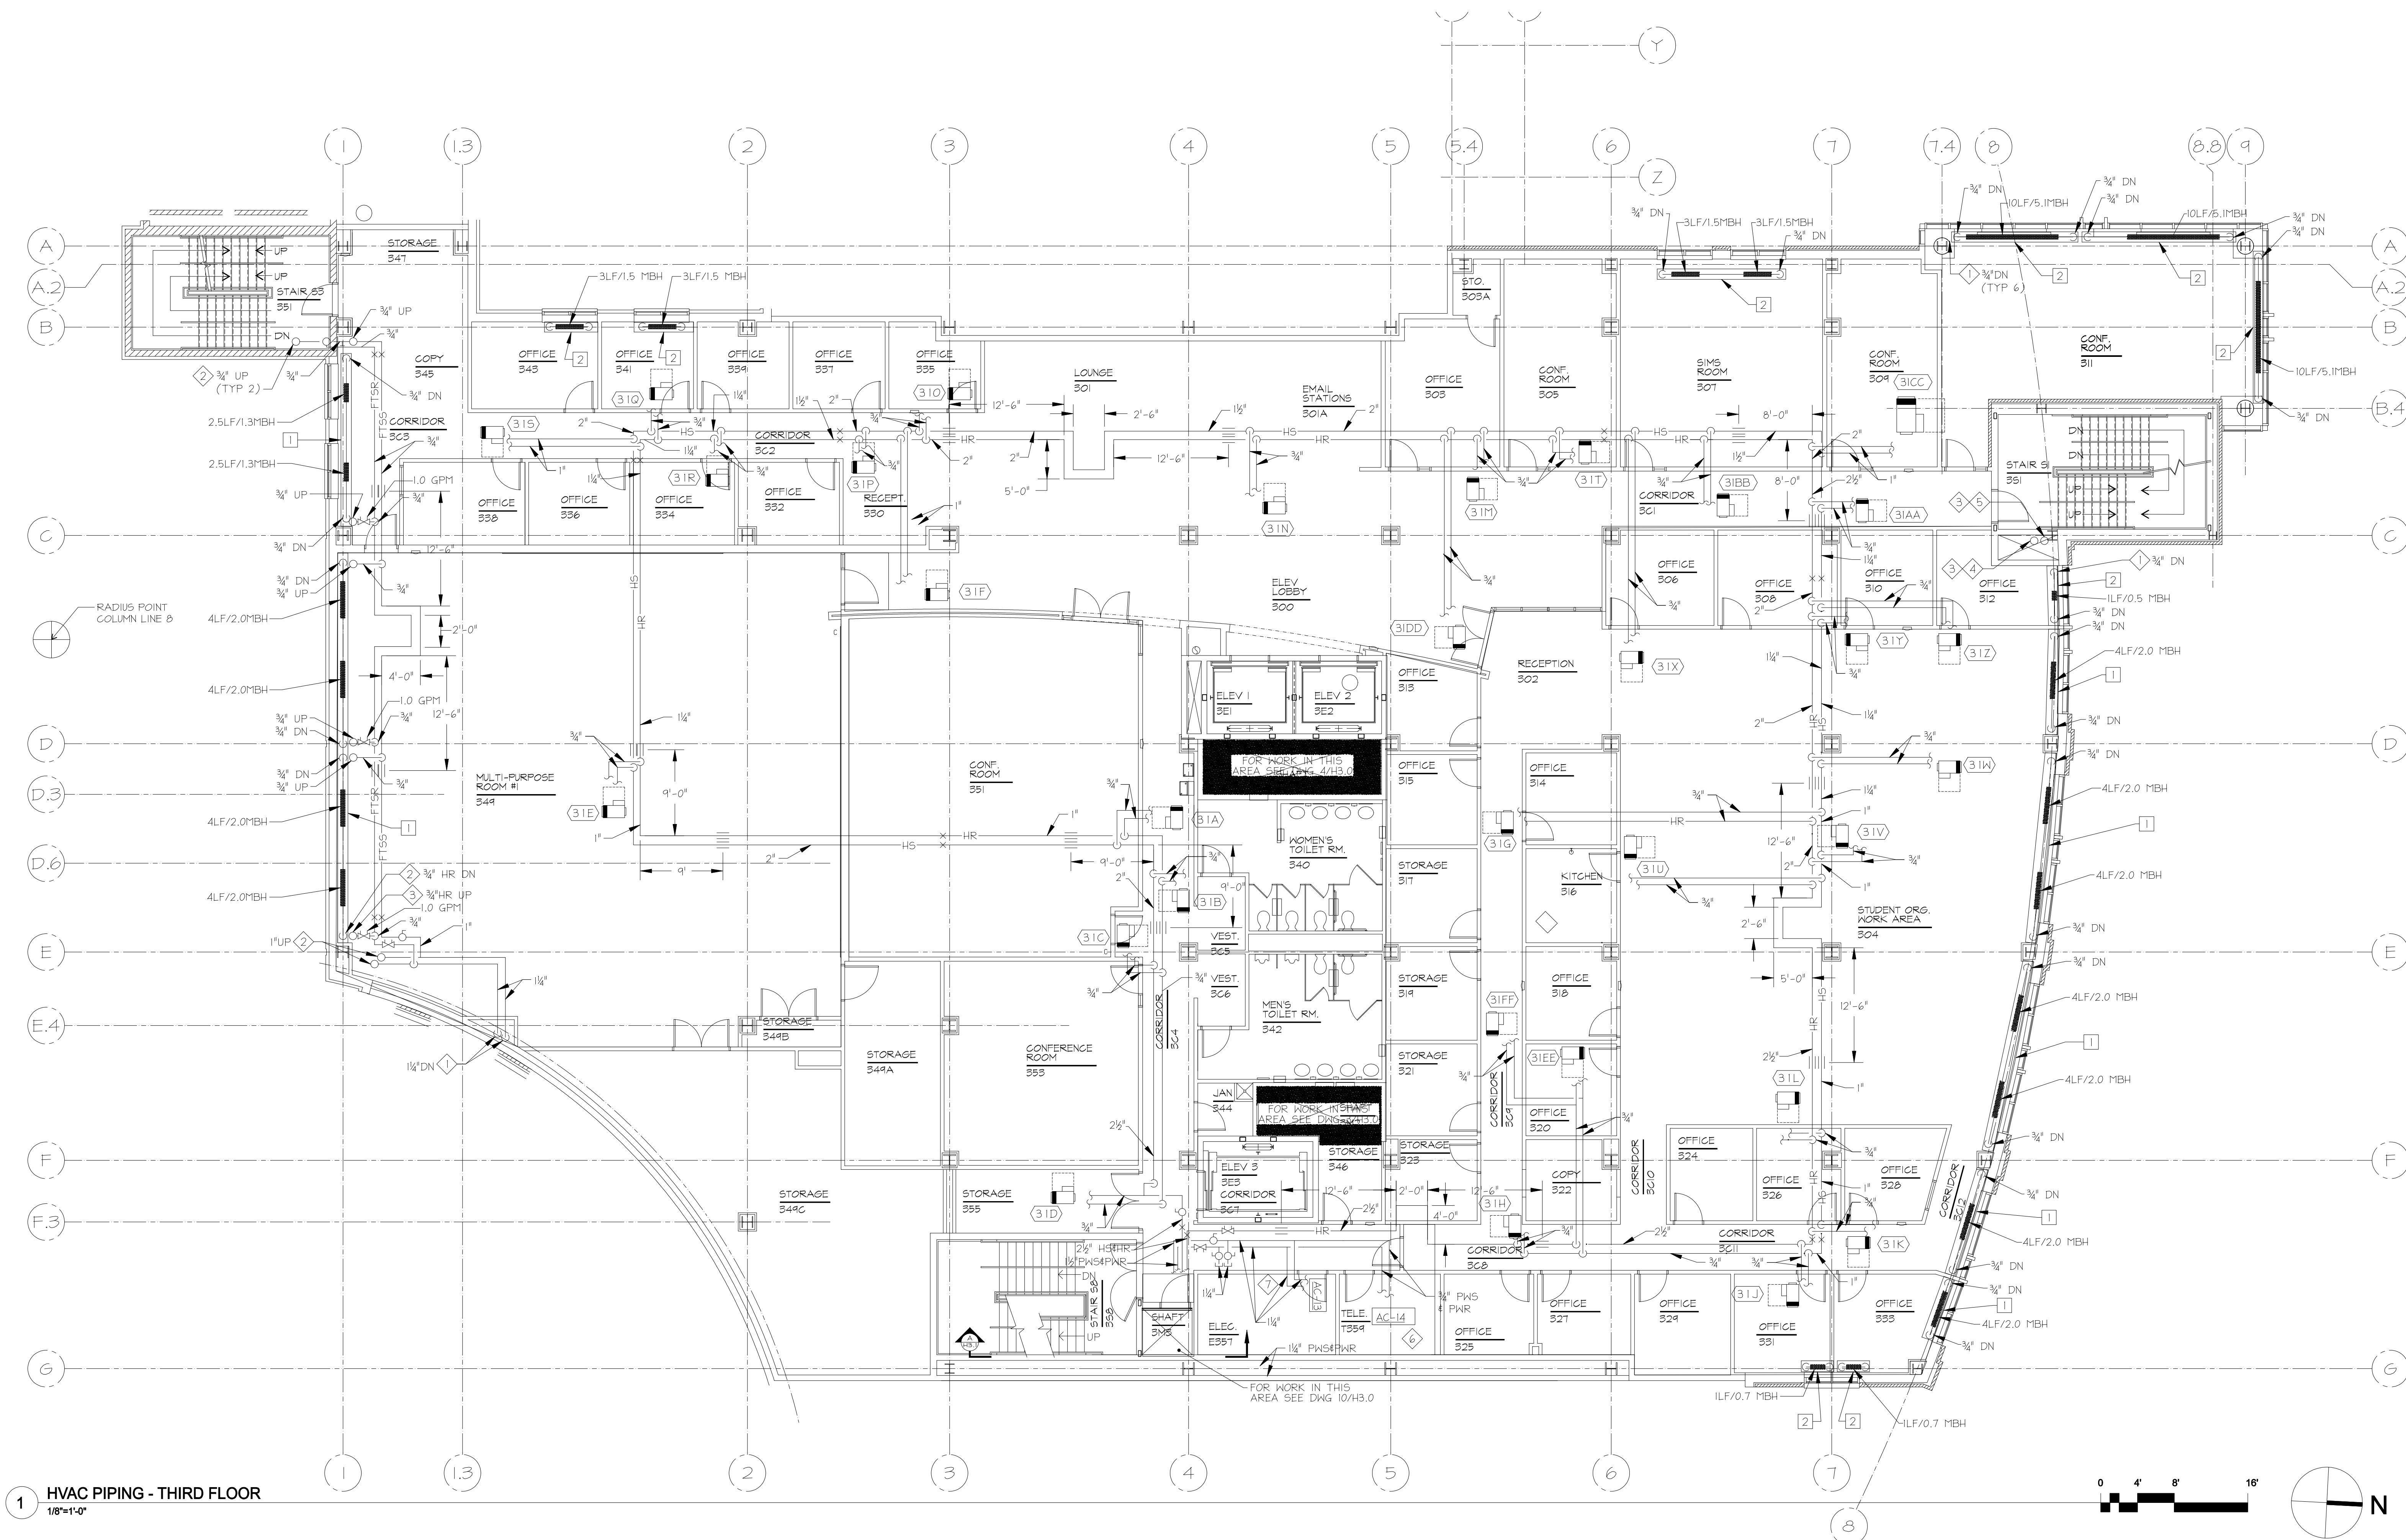

DRAWING NOTES:

1. AT EXTERIOR WALLS, SLAB PENETRATIONS OF FINNED TUBE SYSTEM PIPING SHALL BE BETWEEN BEAM AND WALL.

◇ SPECIAL NOTES:

- 1 H54HR DN TO SECOND FLOOR, FOR CONTINUATION SEE H2-2.
- 2 H54HR UP TO FOURTH FLOOR, FOR CONTINUATION SEE H2-4.
- 3 1½" FTRN UP 4 DN.
- 4 1½" FTRN UP 4 DN.
- 5 FOR CONTINUATION UP, SEE DWG. H2.3A.
- 6 SEE DWG. H3.5 FOR DETAILED LAYOUT. PROVIDE DRAIN PAN UNDER UNIT AND ASSOCIATED PIPING WITHIN ROOM.
- 7 COORDINATE PIPING TO MAINTAIN CODE CLEARANCES WITHIN ELECTRICAL ROOM.

RECORD DRAWING: This record drawing has been prepared based upon information provided by others. While this information is believed to be reliable, the Design Professional has not verified its accuracy, and thus is not responsible for the accuracy or completeness of this record drawing or for any errors or omissions which may have been incorporated into it as a result of erroneous information provided by others. Those relying on this record document are advised to obtain independent verification of its accuracy before applying it to any purpose.



TIMBER COURT
127 ANDERSON STREET
PITTSBURGH, PA 15212-6801
(412) 321-5555
(412) 321-3431 FAX

ASSOCIATE ARCHITECT:



WBCM, - Architects
Whitney Bailey Cox &
Magnoni, LLC -
Consulting Engineers
849 Fairmount Ave. Suite 100
Baltimore, MD 21286 (410) 512-4500

Henry Adams, LLC.
Consulting Engineers



600 Baltimore Avenue
Baltimore, MD 21204-4079
410.296.6500
Fax 410.296.3156

Mullins
Engineering Co.

1227 ANAPOLIS ROAD
ODDINGTON, MD 21113
410-519-0800
FAX 410-672-3973
MEC PROJECT NO. 0512300

20	1/29/10	RECORD DRAWING
19	8/4/09	BULLETIN #101
18	4/29/09	BULLETIN #100
17	4/20/09	BULLETIN #100R
16	3/30/09	BULLETIN #100
15	4/15/09	BULLETIN #99R
14	3/2/09	BULLETIN #94
13	12/16/08	BULLETIN #92
12	12/7/08	BULLETIN #90
11	11/20/08	BULLETIN #79
10	11/19/08	BULLETIN #72 (rev)
9	10/20/08	BULLETIN #69
8	9/4/08	BULLETIN #63
7	7/28/08	BULLETIN #55
6	6/23/08	BULLETIN #51
5	05/23/08	COORD. DWGS RFI 163
4	05/09/08	BULLETIN #31
3	04/14/08	CBM-39
2	03/10/08	CBM-2
1	02/18/08	CBM-1
0	05/02/07	For Construction
Rev.	Date:	Comment:

Issued: May 2, 2007

Campus Center


621 West Lombard Street
University of Maryland,
Baltimore
Baltimore, MD

HVAC Piping Lower Pool Level


100% CONSTRUCTION
DOCUMENTS

UMB PROJECT NO. 99-311
WTC PROJECT NO. 70-4091
© WTC ARCHITECTS \$(edit)\$(REV)\$(yyyy)

H2.3A

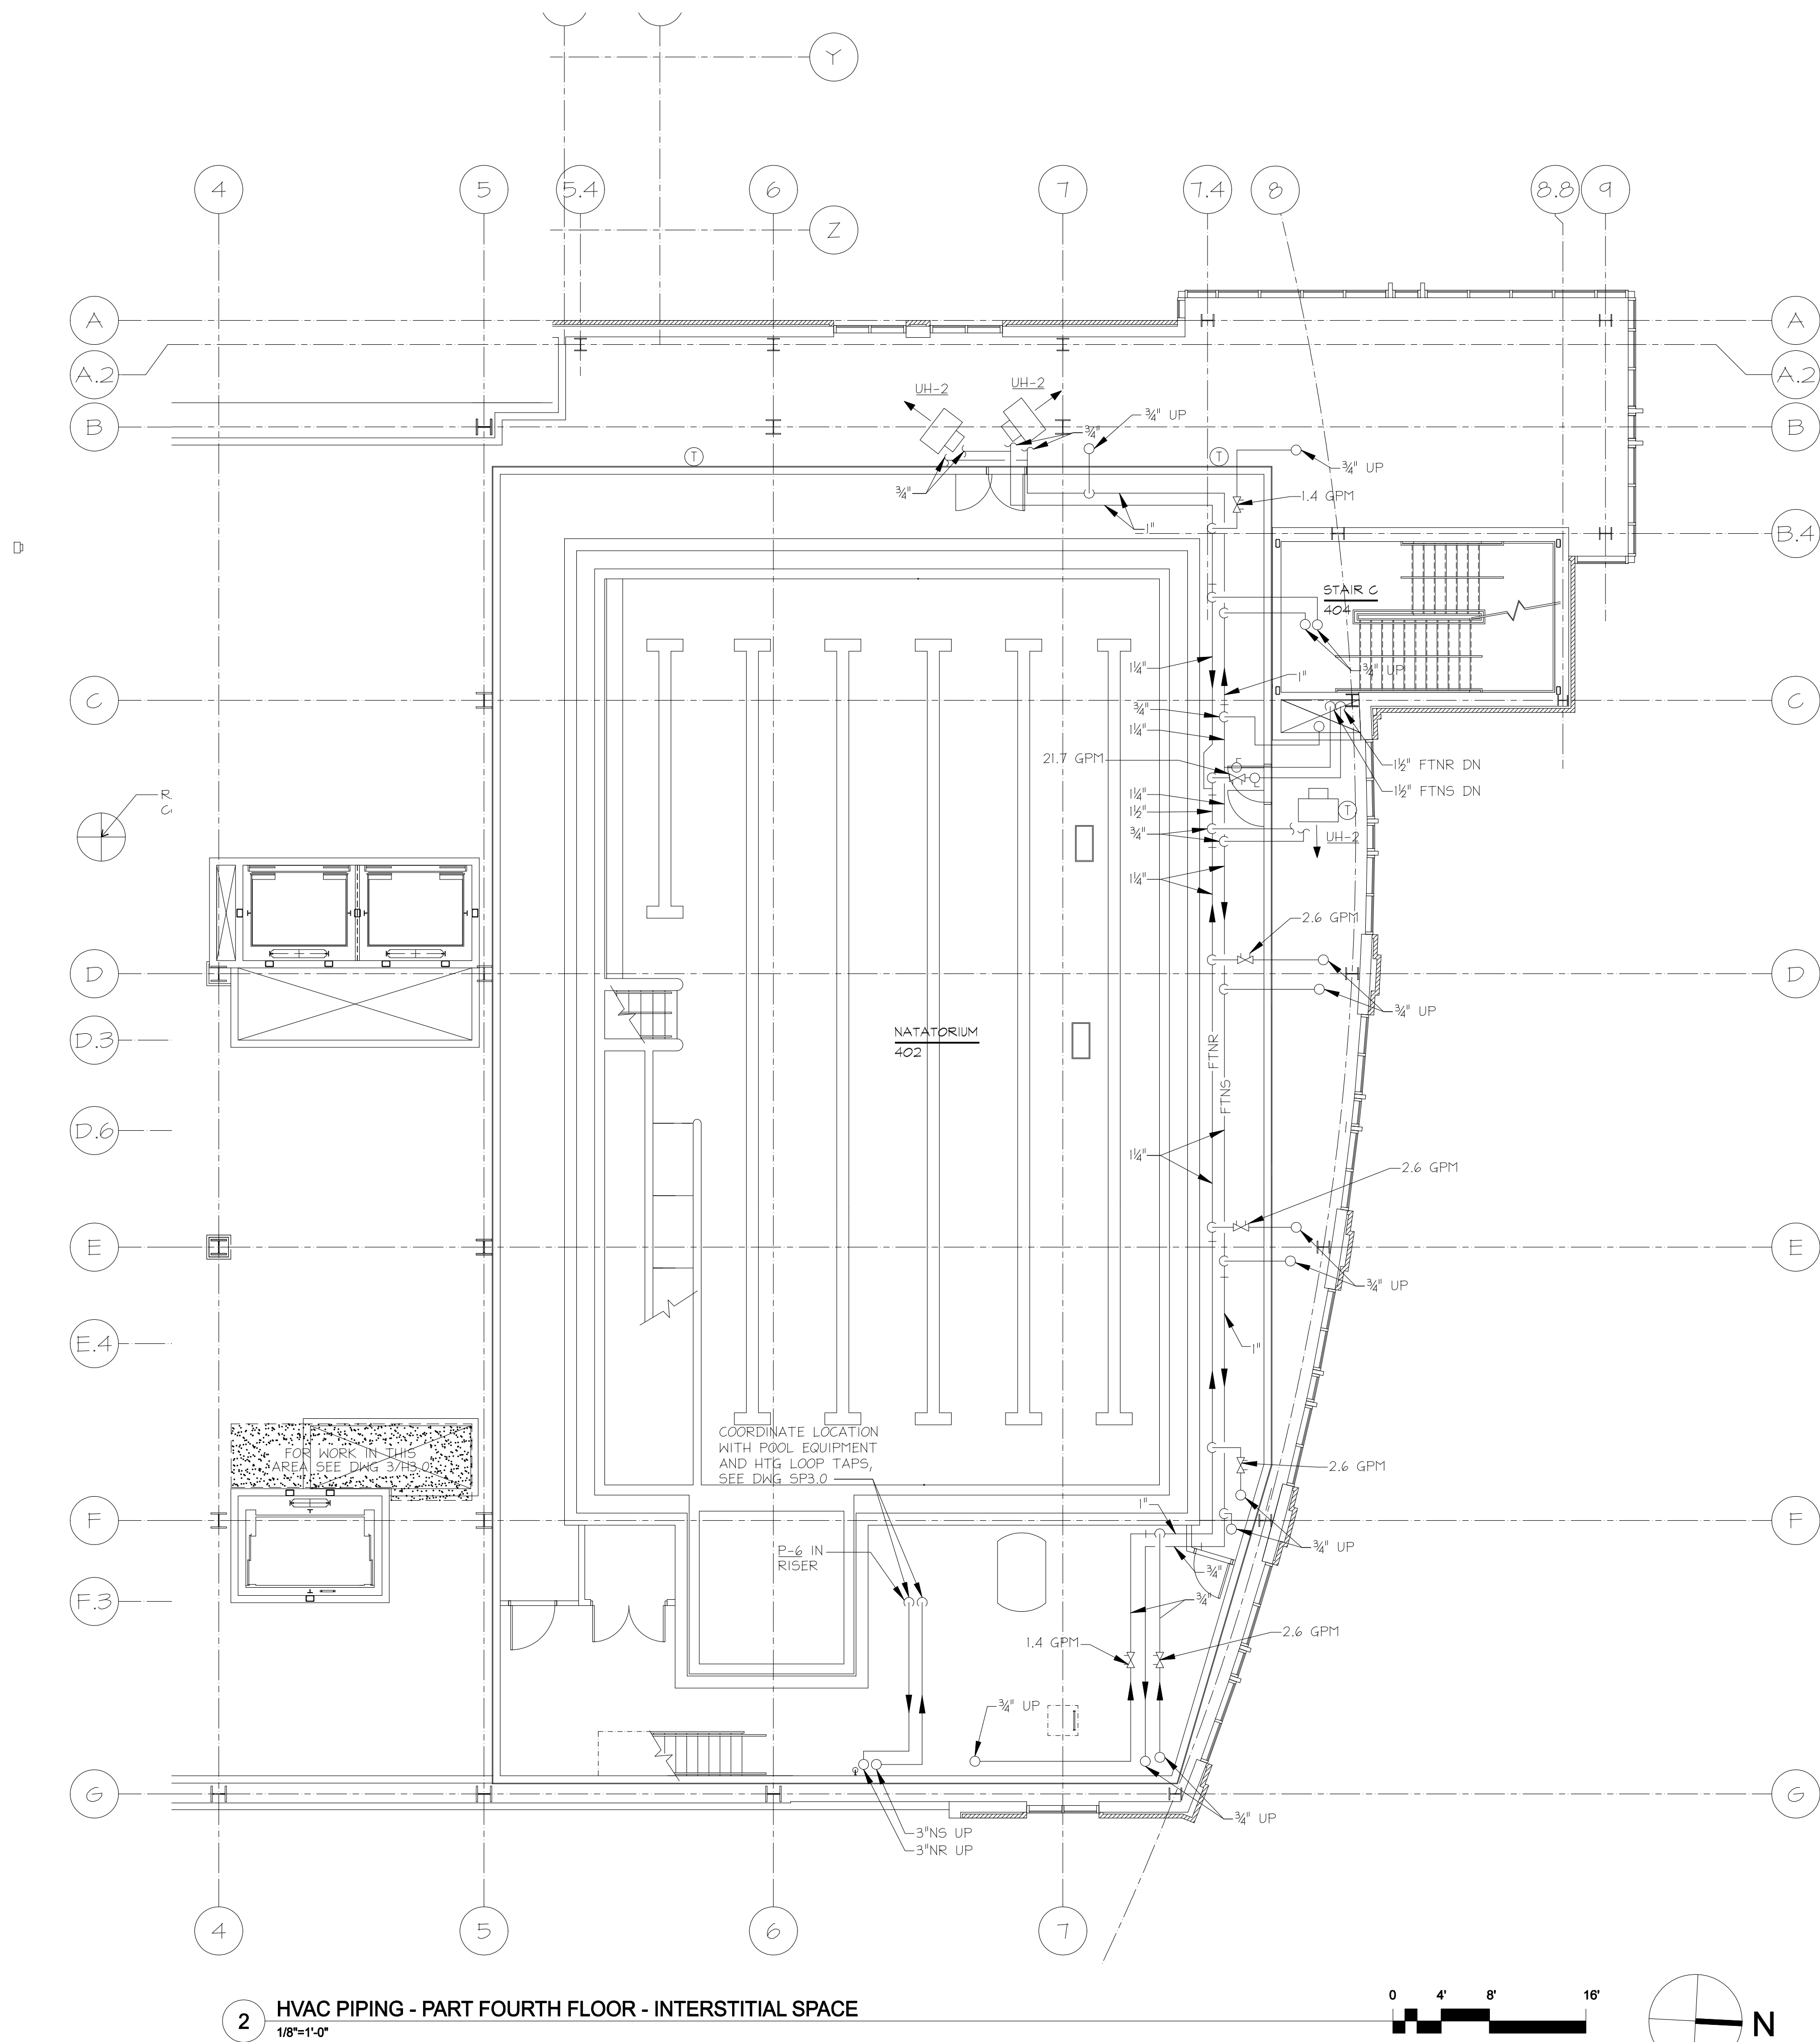

2 HVAC PIPING - PART FOURTH FLOOR - INTERSTITIAL SPACE
1/8"=1'-0"

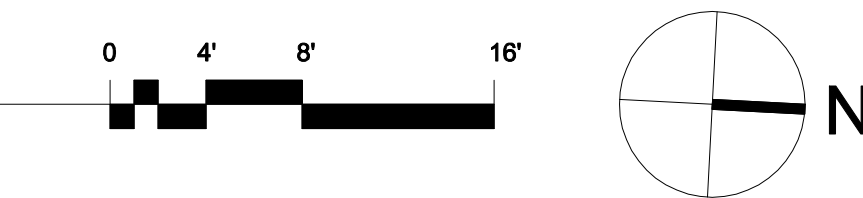

◇ SPECIAL NOTES:

RECORD DRAWING: This record drawing has been prepared based upon information provided by others. While this information is believed to be reliable, the Design Professional has not verified its accuracy, and thus is not responsible for the accuracy or completeness of this record drawing or for any errors or omissions which may have been incorporated into it as a result of erroneous information provided by others. Those relying on this record document are advised to obtain independent verification of its accuracy before applying it for any purpose.

IF THIS DRAWING DOES NOT MEASURE EXACTLY 36" X 42", IT HAS BEEN REDUCED OR ENLARGED. PLEASE DO NOT SCALE THIS DRAWING.



TIMBER COURT
127 ANDERSON STREET
PITTSBURGH, PA 15212-5801
(412) 321-5555
(412) 321-3431 FAX

ASSOCIATE ARCHITECT:



WBCM, - Architects
Whitney Bailey Cox &
Magnani, LLC -
Consulting Engineers
849 Fairmount Ave. Suite 100
Baltimore, MD 21286 (410) 512-4500

Henry Adams, LLC.
Consulting Engineers



600 Baltimore Avenue
Baltimore, MD 21204-4079
410.296.6500
Fax 410.296.3156

Mullins
Engineering Co.

1221 ANAPOLIS ROAD
Baltimore, MD 21113
410-519-0800
FAX 410-512-3971
WEC PROJECT NO. 0512300

20	1/29/10	RECORD DRAWING
19	8/4/09	BULLETIN #101
18	4/29/09	BULLETIN #100
17	4/30/09	BULLETIN #100R
16	3/30/09	BULLETIN #100R
15	4/15/09	BULLETIN #99R
14	3/2/09	BULLETIN #94
13	12/16/08	BULLETIN #92
12	12/7/08	BULLETIN #90
11	11/20/08	BULLETIN #79
10	11/19/08	BULLETIN #72 (rev)
9	10/20/08	BULLETIN #69
8	9/4/08	BULLETIN #63
7	7/28/08	BULLETIN #55
6	6/23/08	BULLETIN #51
5	05/23/08	COORD. DWGS RFI 163
4	05/09/08	BULLETIN #31
3	04/14/08	CBM-39
2	03/10/08	CBM-2
1	02/18/08	CBM-1
0	05/02/07	For Construction
Rev.	Date:	Comment:

Issued: May 2, 2007

Campus Center

621 West Lombard Street
University of Maryland,
Baltimore
Baltimore, MD


HVAC Piping Fourth Floor

100% CONSTRUCTION
DOCUMENTS


UMB PROJECT NO. 99-311
WITW PROJECT NO. 70-4091
© WITW ARCHITECTS S(edin)RE V(0) yyyy)

H2.4


IF THIS DRAWING DOES NOT MEASURE EXACTLY 36" X 42", IT HAS BEEN REDUCED OR ENLARGED. PLEASE DO NOT SCALE THIS DRAWING.

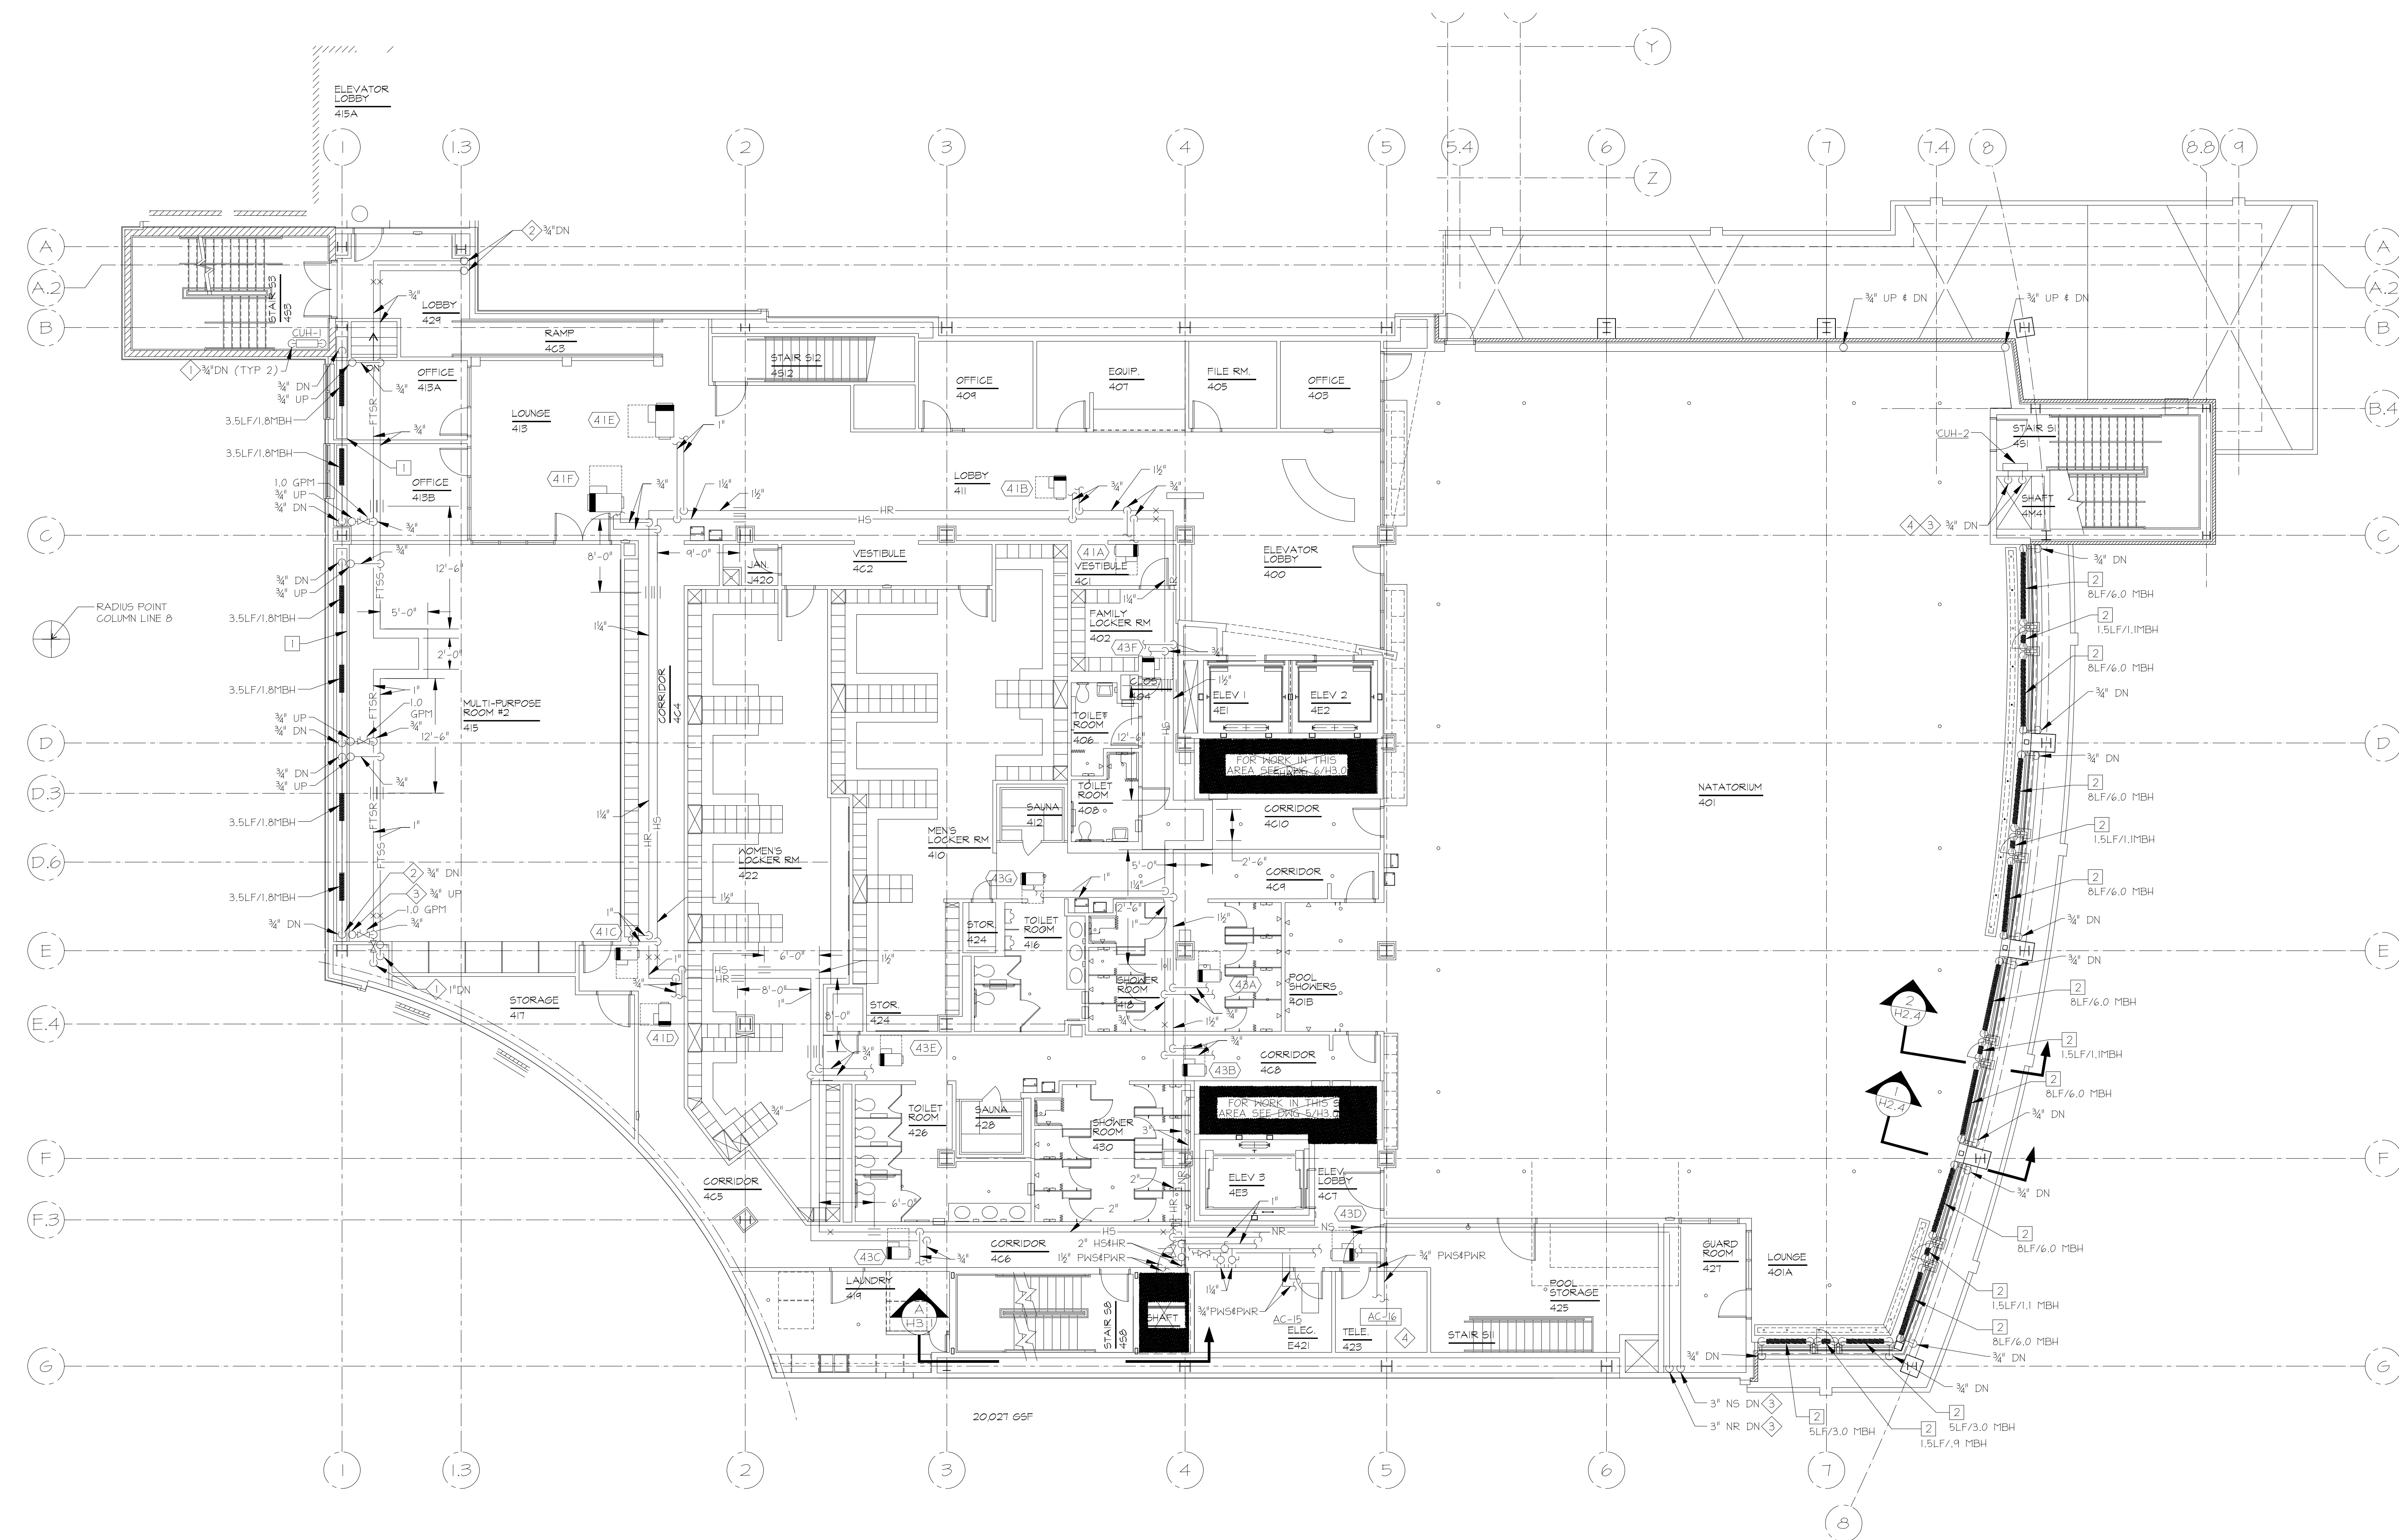


1 HVAC PIPING - FOURTH FLOOR 1/8\"=1'-0"

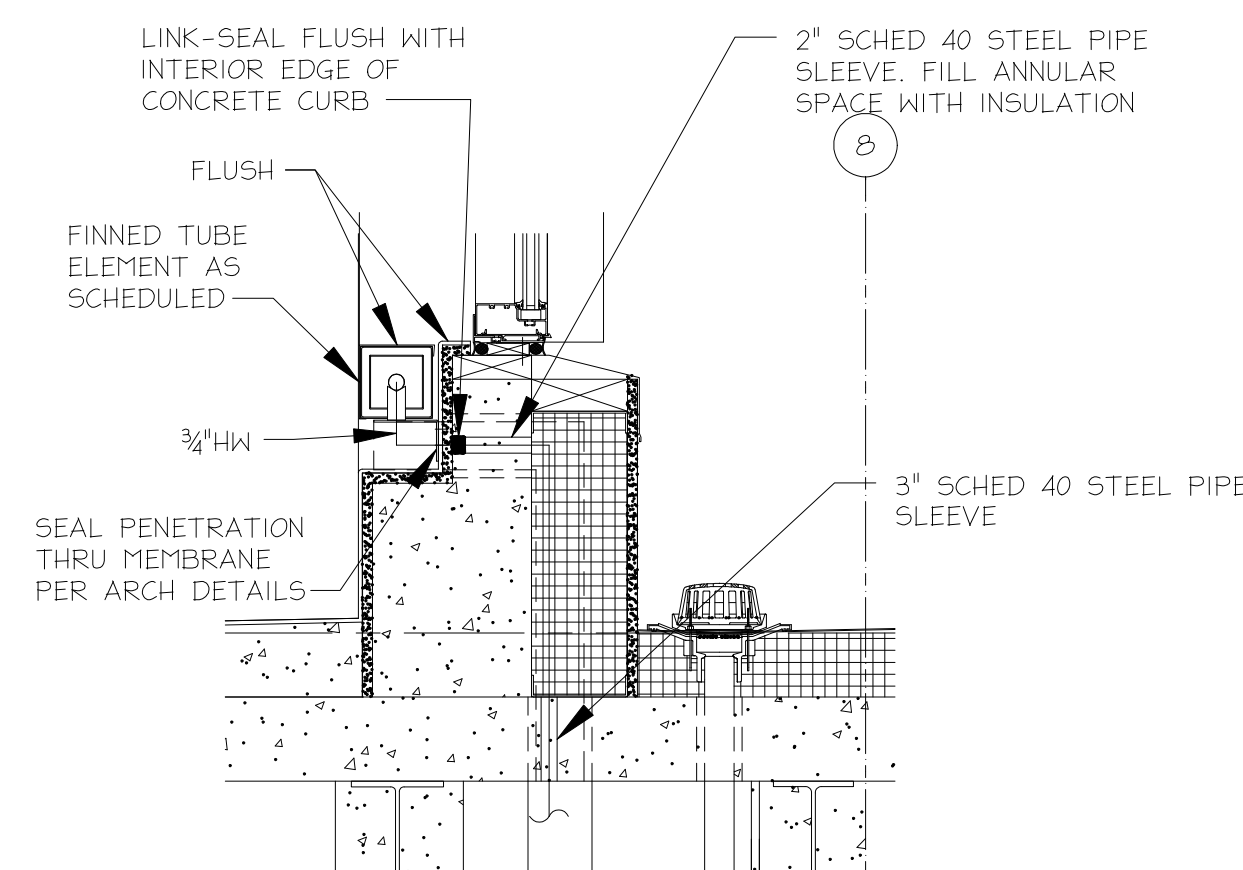

2 SECTION 1/H2.4 1\"=1'-0"

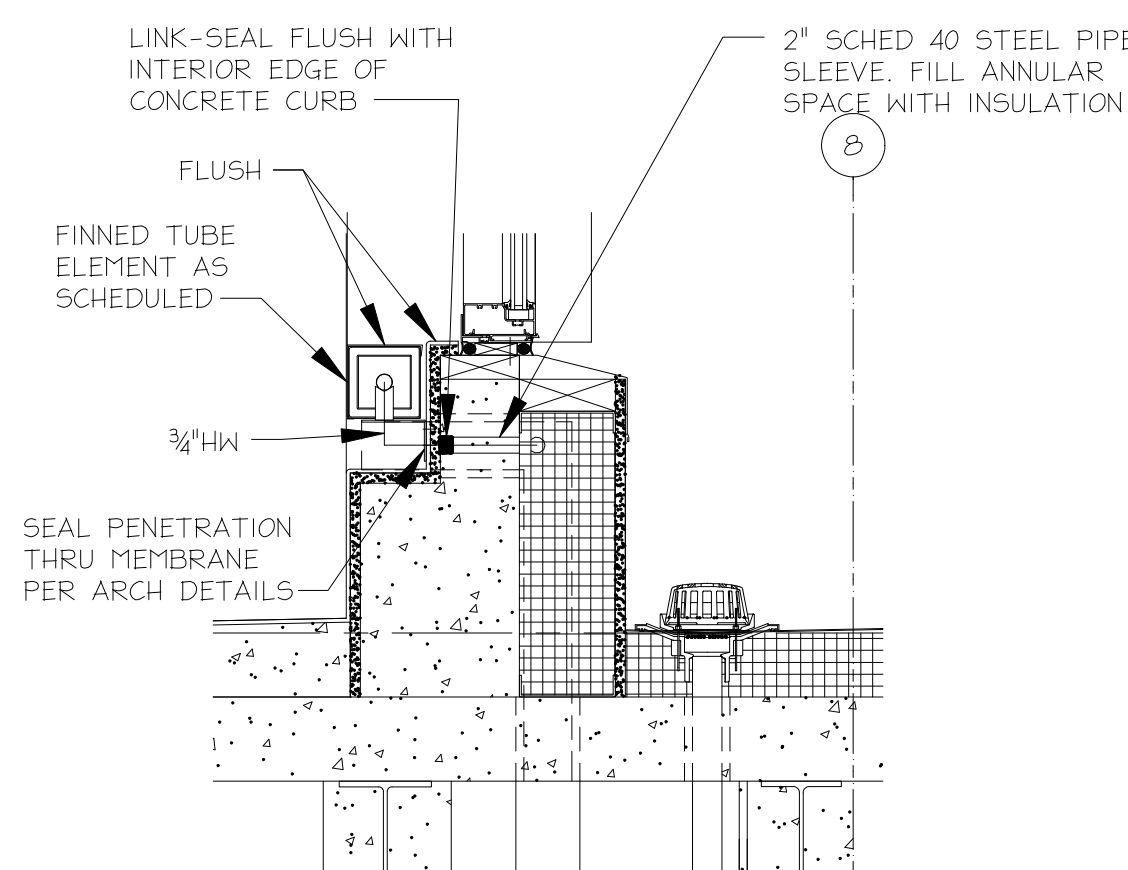

3 SECTION 2/H2.4 1\"=1'-0"

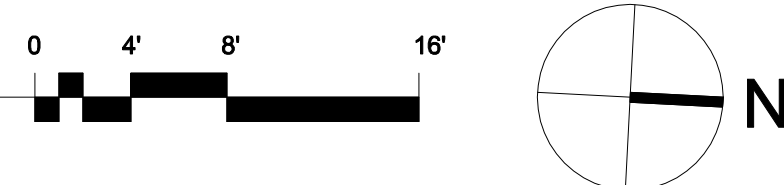

SPECIAL NOTES:

- H54HR DN TO THIRD FLOOR CEILING, FOR CONTINUATION SEE H2-3.
- H54HR UP TO FIFTH FLOOR, FOR CONTINUATION SEE H2-5.
- DN TO NATATORIUM UNDERFLOOR SPACE, FOR CONTINUATION SEE H2-3A.
- SEE DWG. H3.5 FOR DETAILED LAYOUT. PROVIDE DRAIN PAN UNDER UNIT AND ASSOCIATED PIPING WITHIN ROOM.

RECORD DRAWING: This record drawing has been prepared based upon information provided by others. While this information is believed to be reliable, the Design Professional has not verified its accuracy, and thus is not responsible for the accuracy or completeness of this record drawing or for any errors or omissions which may have been incorporated into it as a result of erroneous information provided by others. Those relying on this record document are advised to obtain independent verification of its accuracy before applying it for any purpose.



TIMBER COURT
127 ANDERSON STREET
PITTSBURGH, PA 15212-5801
(412) 321-5555
(412) 321-2431 FAX

ASSOCIATE ARCHITECT:



WBCM, - Architects
Whitney Bailey Cox &
Magnani, LLC -
Consulting Engineers
849 Fairmount Ave. Suite 100
Baltimore, MD 21286 (410) 512-4500

Henry Adams, LLC.
Consulting Engineers



600 Baltimore Avenue
Baltimore, MD 21204-4079
410.296.6500
Fax 410.296.3156

Mullins
Engineering Co.

1221 ANAPOLIS ROAD
ODONTON, MD 21113
410-519-6800
FAX 410-512-3973
MEC PROJECT NO. 0512300

20	1/29/10	RECORD DRAWING
19	8/4/09	BULLETIN #101
18	4/29/09	BULLETIN #100
17	4/20/09	BULLETIN #100R
16	3/20/09	BULLETIN #105
15	4/15/09	BULLETIN #095
14	3/2/09	BULLETIN #84
13	12/16/08	BULLETIN #82
12	12/7/08	BULLETIN #80
11	11/20/08	BULLETIN #79
10	11/19/08	BULLETIN #72 (rev)
9	10/20/08	BULLETIN #69
8	9/4/08	BULLETIN #63
7	7/28/08	BULLETIN #55
6	6/23/08	BULLETIN #51
5	05/23/08	COORD. DWGS RFI 163
4	05/09/08	BULLETIN #31
3	04/14/08	CBM-39
2	03/10/08	CBM-2
1	02/18/08	CBM-1
0	05/02/07	For Construction
Rev.	Date:	Comment:

Issued: May 2, 2007

Campus Center


621 West Lombard Street
University of Maryland,
Baltimore
Baltimore, MD

HVAC Piping Fifth Floor

100% CONSTRUCTION
DOCUMENTS

UMB PROJECT NO. 99-311
WTW PROJECT NO. 70-4091
© WTW ARCHITECTS S(editimRE V# yyyy)

H2.5

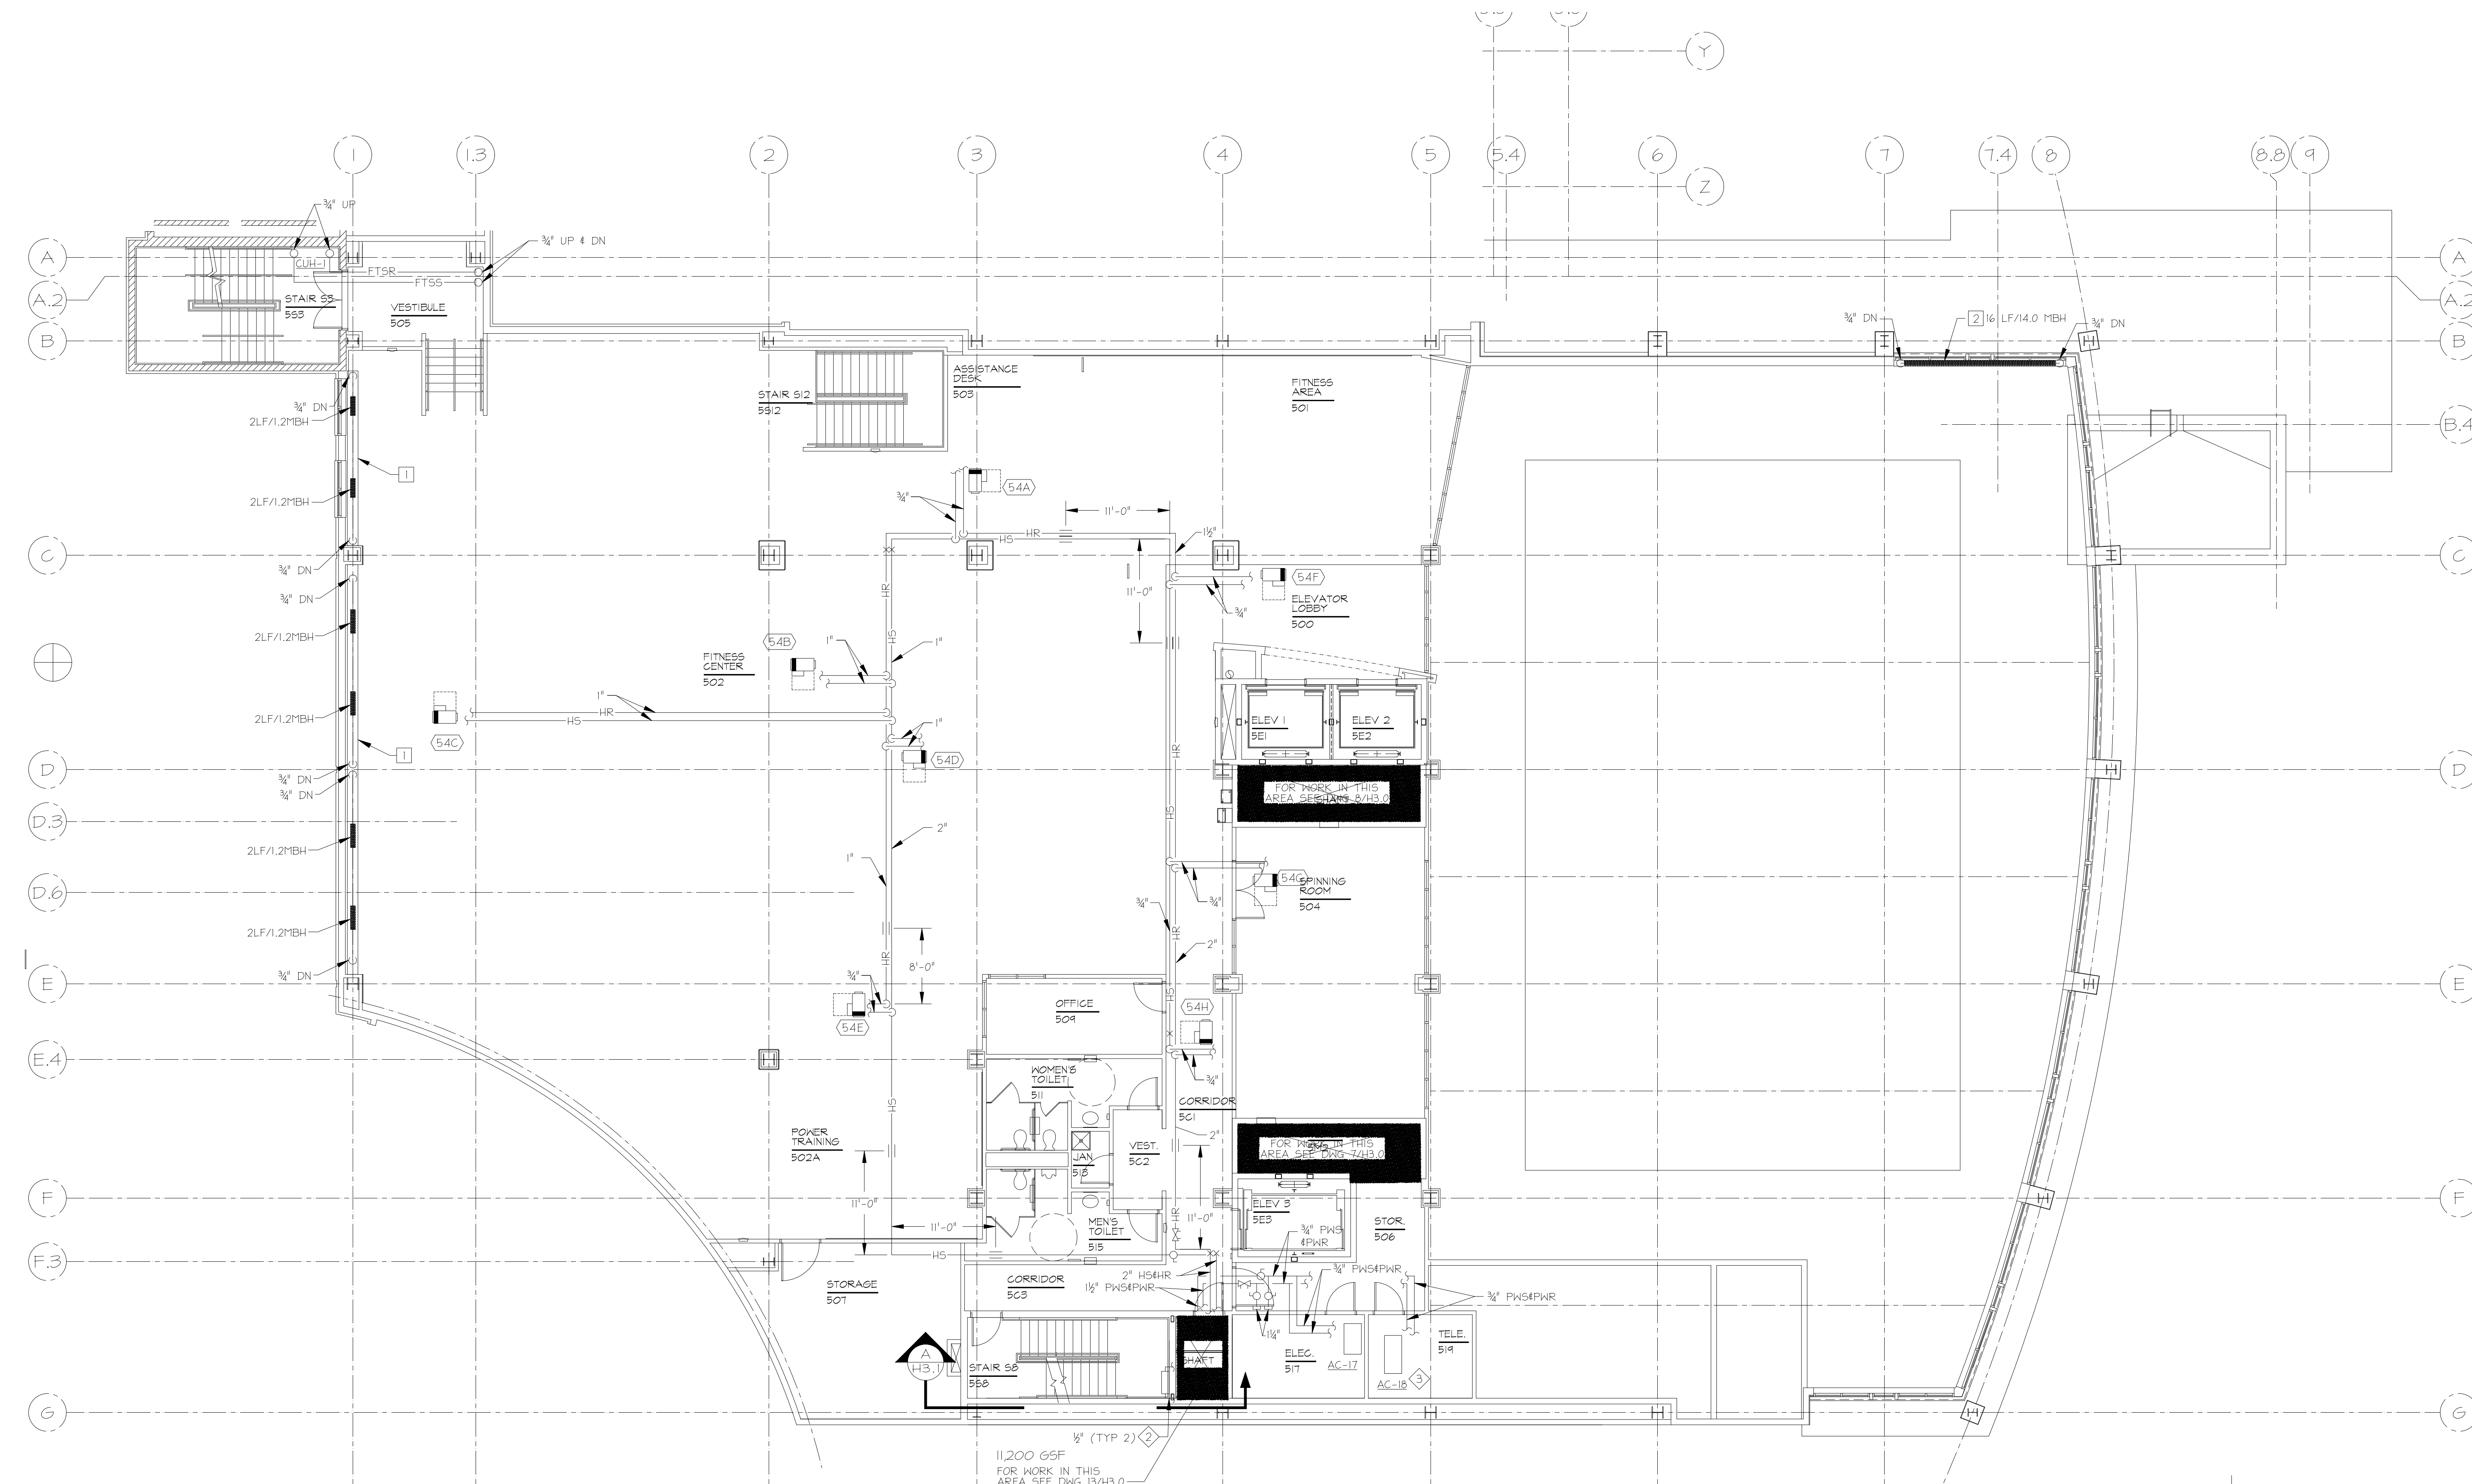

1 HVAC PIPING AND DUCTWORK - FIFTH FLOOR
1/8"=1'-0"



SPECIAL NOTES:

- HS4HR DN TO FOURTH FLOOR, FOR CONTINUATION SEE H2-4.
- PIPE THRU WALL INTO SHAFT, FOR CONTINUATION SEE H3-0.
- SEE DWG. H3.5 FOR DETAILED LAYOUT. PROVIDE DRAIN PANS.

RECORD DRAWING: This record drawing has been prepared based upon information provided by others. While this information is believed to be reliable, the Design Professional has not verified its accuracy, and thus is not responsible for the accuracy or completeness of this record drawing or for any errors or omissions which may have been incorporated into it as a result of erroneous information provided by others. Those relying on this record document are advised to obtain independent verification of its accuracy before applying it for any purpose.

IF THIS DRAWING DOES NOT MEASURE EXACTLY 36" X 42", IT HAS BEEN REDUCED OR ENLARGED. PLEASE DO NOT SCALE THIS DRAWING.



TIMBER COURT
127 ANDERSON STREET
PITTSBURGH, PA 15212-6801
(412) 321-5555
(412) 321-2431 FAX

ASSOCIATE ARCHITECT:



WBCM, - Architects
Whitney Bailey Cox &
Magnani, LLC -
Consulting Engineers
849 Fairmount Ave. Suite 100
Baltimore, MD 21286 (410) 512-4500

Henry Adams, LLC.
Consulting Engineers



600 Baltimore Avenue
Baltimore, MD 21204-4079
410.296.6500
Fax 410.296.3156

Mullins
Engineering Co.

1221 ANAPOLIS ROAD
ODDINGTON, MD 21113
410-519-0800
FAX 410-519-0971
MEC PROJECT NO. 0512300

20	1/29/10	RECORD DRAWING
19	8/4/09	BULLETIN #103
18	4/29/09	BULLETIN #108
17	4/20/09	BULLETIN #108R
16	3/30/09	BULLETIN #105
15	4/15/09	BULLETIN #095
14	3/2/09	BULLETIN #84
13	12/16/08	BULLETIN #82
12	12/7/08	BULLETIN #80
11	11/20/08	BULLETIN #79
10	11/19/08	BULLETIN #72 (rev)
9	10/20/08	BULLETIN #69
8	9/4/08	BULLETIN #63
7	7/28/08	BULLETIN #55
6	6/23/08	BULLETIN #51
5	05/23/08	COORD. DWGS RFI 163
4	05/09/08	BULLETIN #31
3	04/14/08	CBM-39
2	03/10/08	CBM-2
1	02/18/08	CBM-1
0	05/02/07	For Construction
Rev.	Date:	Comment:

Issued: May 2, 2007

Campus Center

621 West Lombard Street
University of Maryland,
Baltimore
Baltimore, MD

HVAC Penthouse Roof

100% CONSTRUCTION
DOCUMENTS

UMB PROJECT NO. 99-311
WTA PROJECT NO. 70-4091
© WTA ARCHITECTS \$(edit)\$(REV)\$(yyyy)


H2.7

IF THIS DRAWING DOES NOT MEASURE EXACTLY 30" X 42", IT HAS BEEN REDUCED OR ENLARGED. PLEASE DO NOT SCALE THIS DRAWING.

RECORD DRAWING: This record drawing has been prepared based upon information provided by others. While this information is believed to be reliable, the Design Professional has not verified its accuracy, and thus is not responsible for the accuracy or completeness of this record drawing or for any errors or omissions which may have been incorporated into it as a result of erroneous information provided by others. Those relying on this record document are advised to obtain independent verification of its accuracy before applying it for any purpose.

SPECIAL NOTES:

- FOR CONTINUATION, SEE DRAWING HB.3.
- FOR CONTINUATION, SEE DRAWING HI.4
- CAP DUCT ABOVE ROOF CURB
- FUTURE DUCTWORK AND FANS
- LOW-LEAKAGE PARALLEL BLADE DAMPER WITH 24 VDC ACTUATOR, FOR CONNECTION TO AND CONTROL BY FIRE ALARM SYSTEM. DAMPER AND ACTUATOR SHALL BE SUITABLE FOR EXTERIOR INSTALLATION. DAMPER SHALL BE INTERLOCKED WITH FAN SUCH THAT WHEN IT IS OPERATING, DAMPER IS OPEN.

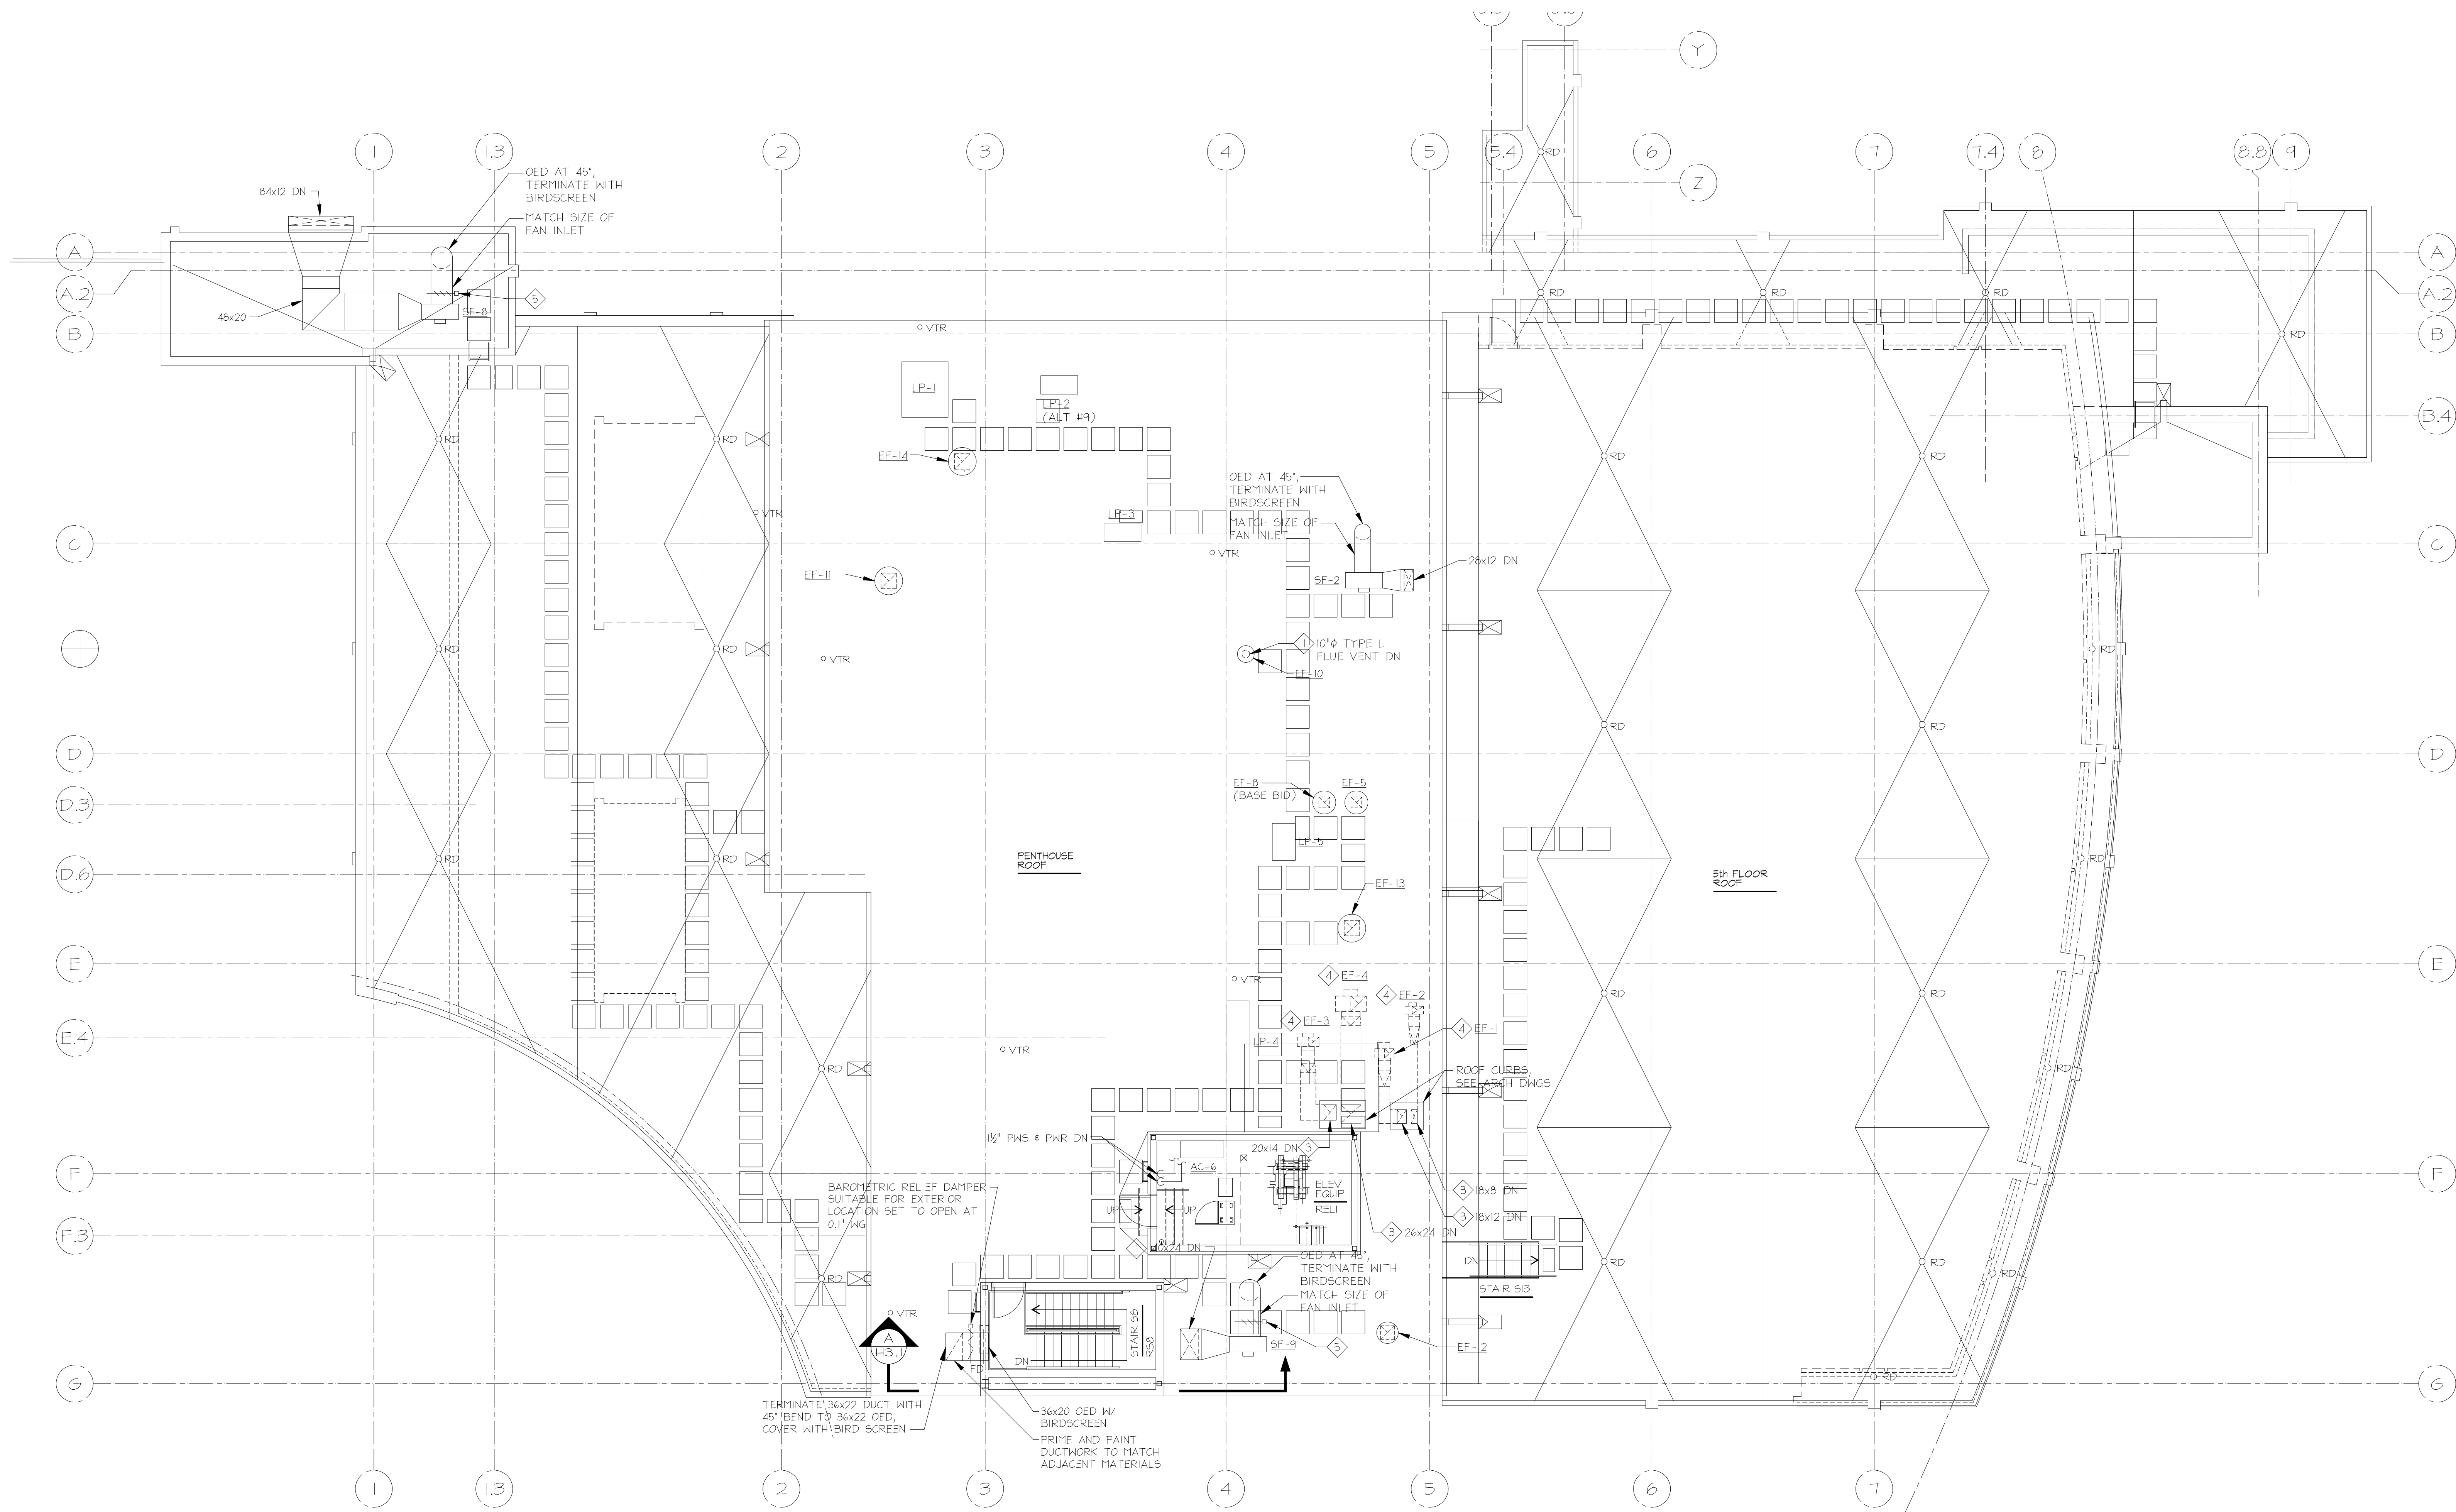

1 HVAC - PENTHOUSE ROOF
1/8"=1'-0"



TIMBER COURT
127 ANDERSON STREET
PITTSBURGH, PA 15212-5801
(412) 321-5555
(412) 321-3431 FAX

ASSOCIATE ARCHITECT:



WBCM, - Architects
Whitney Bailey Cox &
Magnoni, LLC -
Consulting Engineers
849 Fairmount Ave. Suite 100
Baltimore, MD 21286 (410) 512-4500

Henry Adams, LLC.
Consulting Engineers



600 Baltimore Avenue
Baltimore, MD 21204-4079
410.296.6500
Fax 410.296.3156

**Mullins
Engineering Co.**

1221 ANAPOLIS ROAD
ODDINGTON, MD 21113
410-519-0890
FAX 410-523-3973
MEC PROJECT NO. 0512300

20	1/29/10	RECORD DRAWING
19	8/4/09	BULLETIN #201
18	4/29/09	BULLETIN #109
17	4/30/09	BULLETIN #108
16	3/30/09	BULLETIN #105
15	4/15/09	BULLETIN #995
14	3/2/09	BULLETIN #84
13	12/16/08	BULLETIN #82
12	12/7/08	BULLETIN #80
11	11/20/08	BULLETIN #79
10	11/19/08	BULLETIN #72 (rev)
9	10/20/08	BULLETIN #69
8	9/4/08	BULLETIN #63
7	7/28/08	BULLETIN #55
6	6/23/08	BULLETIN #51
5	05/23/08	COORD. DWGS RFI 163
4	05/09/08	BULLETIN #31
3	04/14/08	CBM-39
2	03/10/08	CBM-2
1	02/18/08	CBM-1
0	05/02/07	For Construction
Rev.	Date:	Comment:

Issued: May 2, 2007

Campus Center

621 West Lombard Street
University of Maryland,
Baltimore
Baltimore, MD

DRAWING NOTES:


- ACCESS DOORS ON GREASE EXHAUST DUCTS SHALL BE PROVIDE WITH A SIGN SAYING "ACCESS DOOR - DO NOT OBSTRUCT" PER NFPA%.

SPECIAL NOTES:

- FOR CONTINUATION SEE DRAWING H1.2.
- FOR CONTINUATION SEE DRAWING H1.3.
- FOR CONTINUATION SEE DRAWING H1.4.
- FOR CONTINUATION SEE DRAWING H1.3A.
- FOR CONTINUATION SEE DRAWING H2.1.
- FOR CONTINUATION SEE DRAWING H2.2.
- FOR CONTINUATION SEE DRAWING H2.3.
- FOR CONTINUATION SEE DRAWING H2.4.
- FOR CONTINUATION SEE DRAWING H2.5.
- UTILIZE FIRE-RATED DUCTWRAP AS SPECIFIED. DO NOT INSTALL FIRE DAMPER AT SHAFT WALL.
- FOR CONTINUATION SEE DRAWING H2.4.
- PROVIDE FIRE RATED ACCESS DOOR AT BOTTOM OF RISERS.
- FOR CONTINUATION UP, SEE DRAWING H3.3.
- FOR CONTINUATION, SEE DRAWING H3.1.
- PROVIDE UNDER ALT. #2.

RECORD DRAWING: This record drawing has been prepared based upon information provided by others. While this information is believed to be reliable, the Design Professional has not verified its accuracy, and thus is not responsible for the accuracy or completeness of this record drawing or for any errors or omissions which may have been incorporated into it as a result of erroneous information provided by others. Those relying on this record document are advised to obtain independent verification of its accuracy before applying it for any purpose.














0 2' 4' 8'
SCALE 1/4"=1'-0"

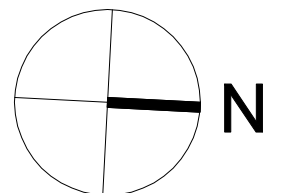


IF THIS DRAWING DOES NOT MEASURE EXACTLY 36" X 42", IT HAS BEEN REDUCED OR ENLARGED. PLEASE DO NOT SCALE THIS DRAWING.




UMB PROJECT NO. 99-311
WTW PROJECT NO. 70-4091
© WTW ARCHITECTS S(edin)RE(0) (yyyy)

H3.0

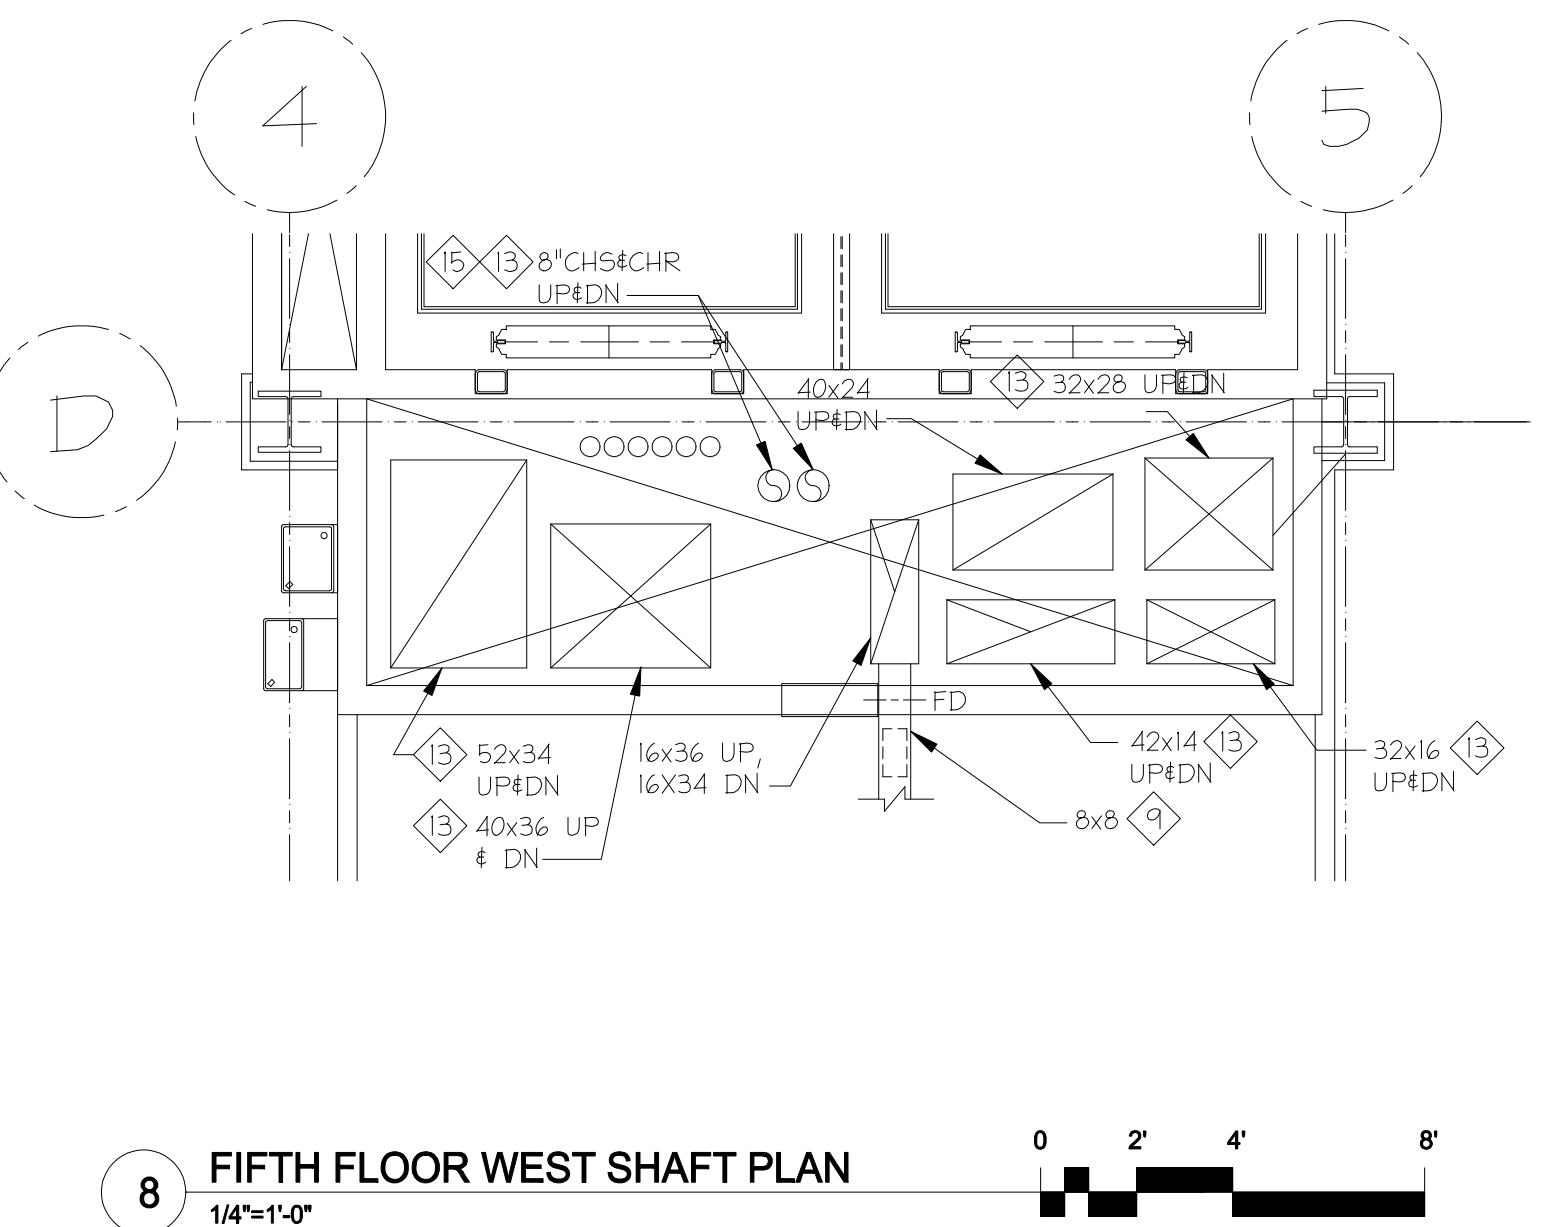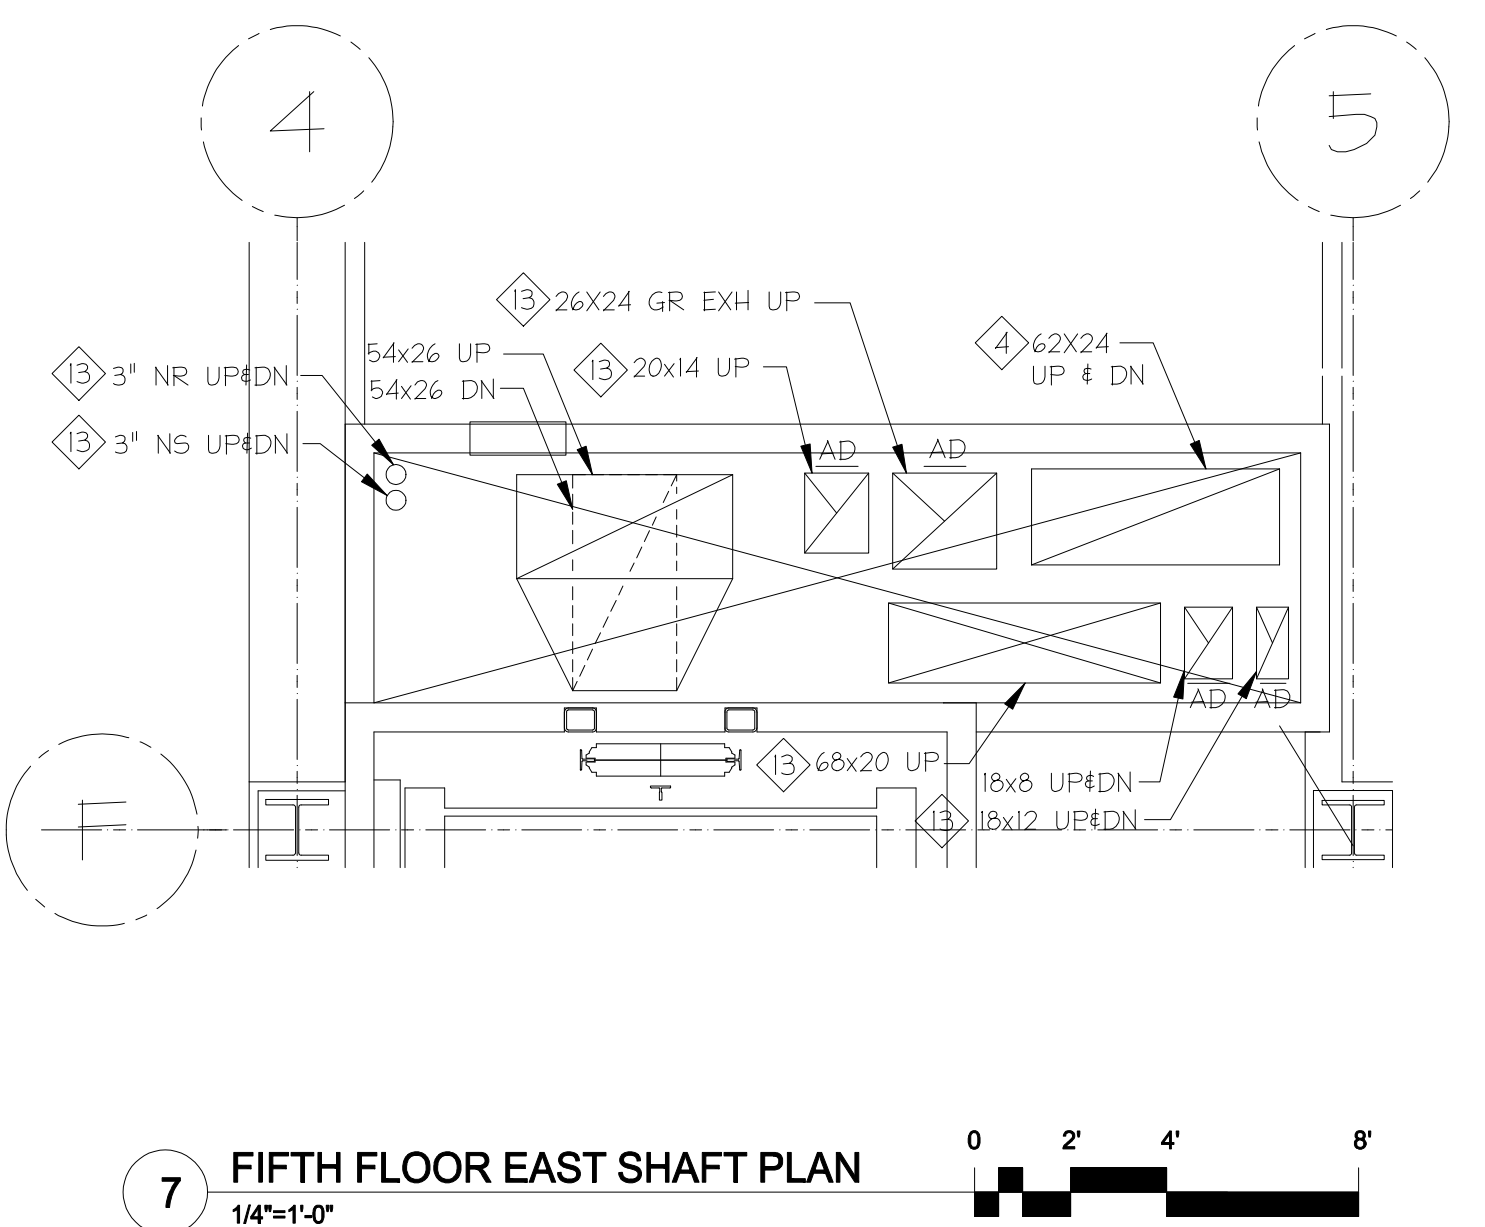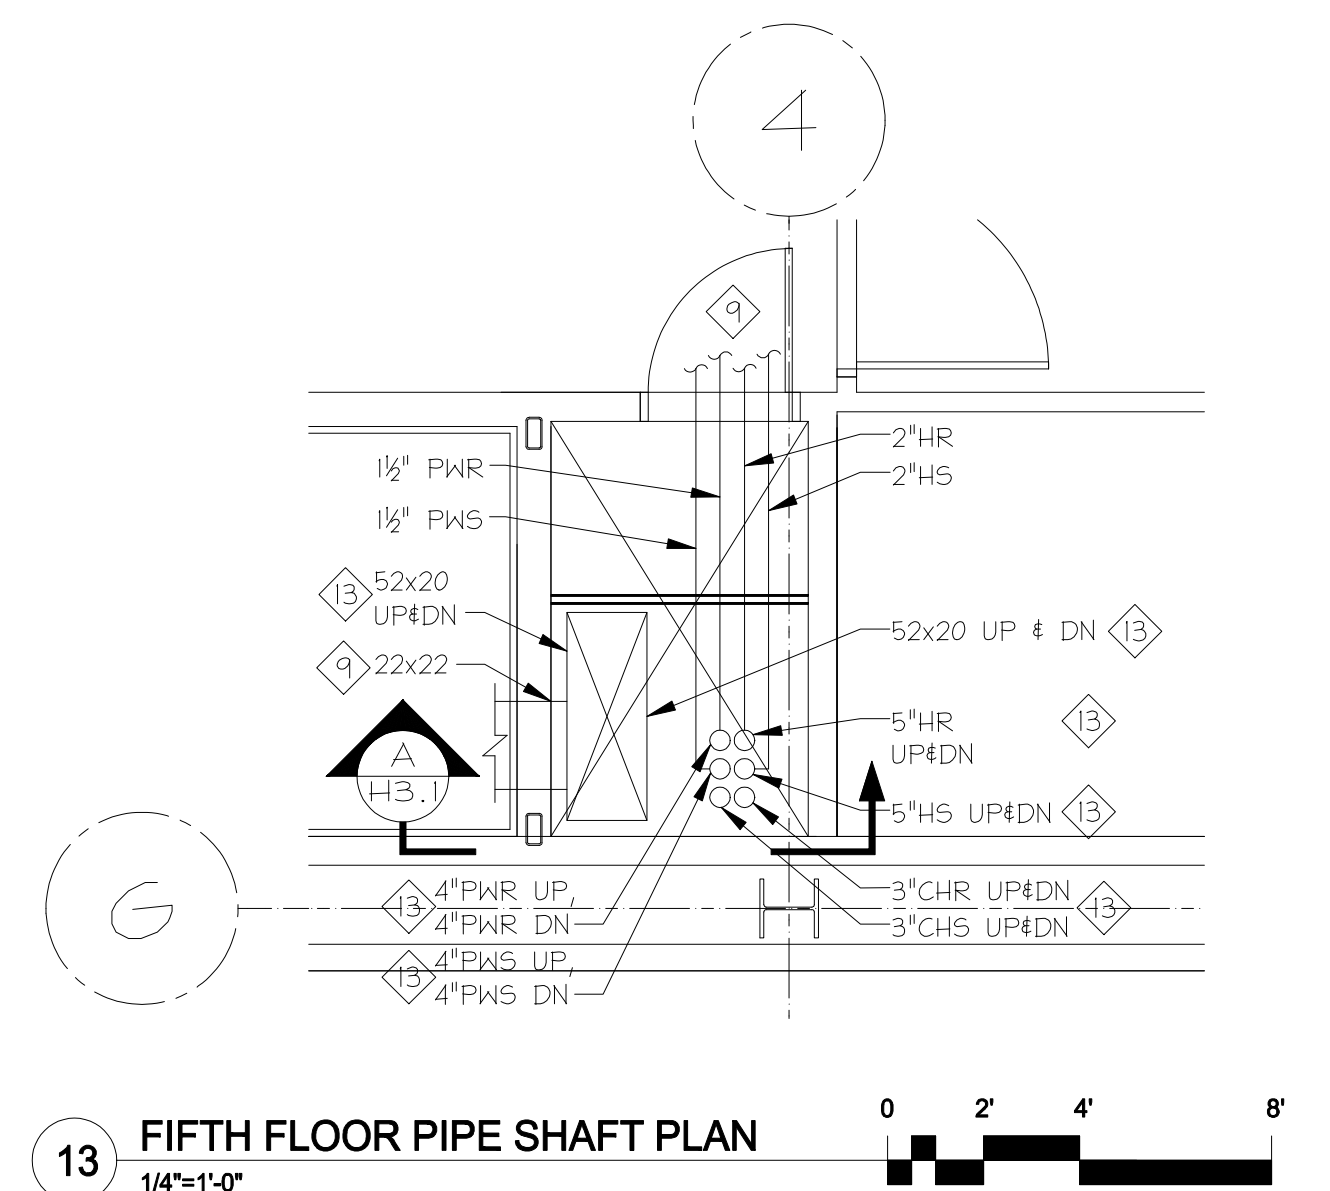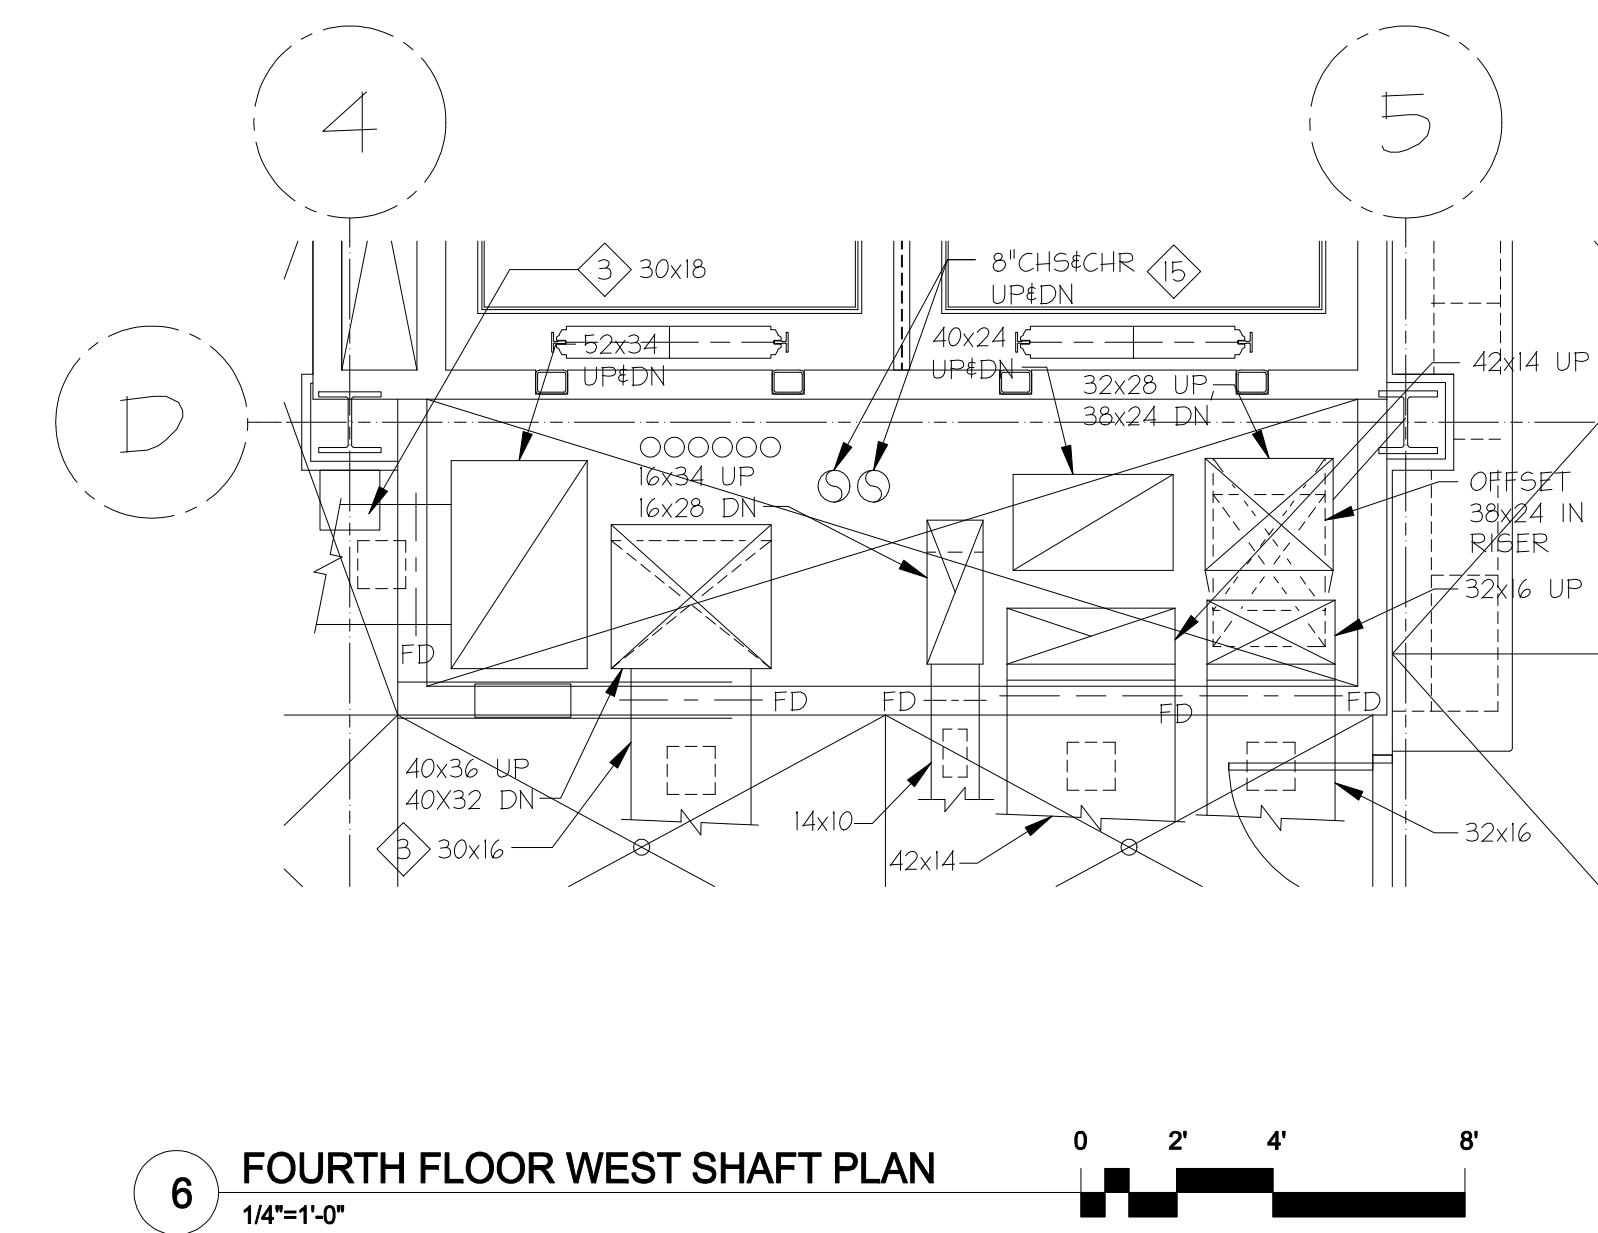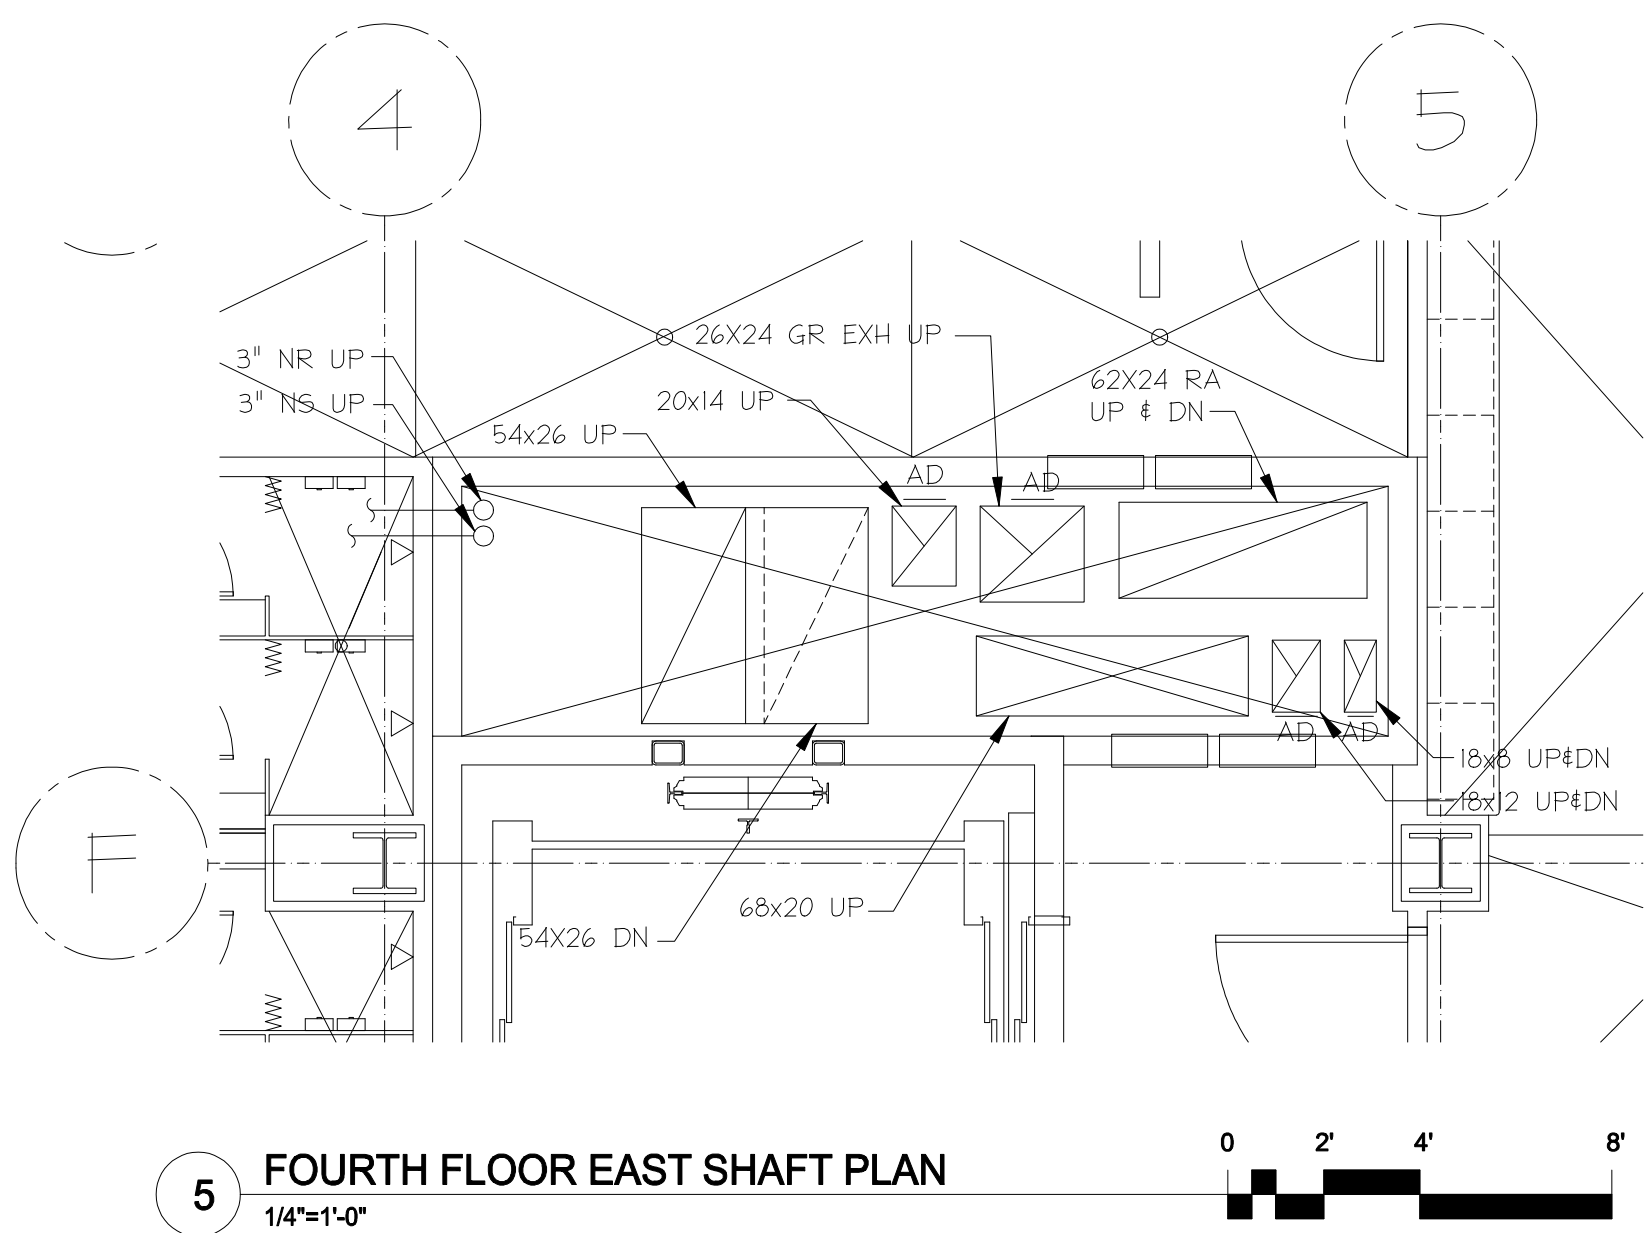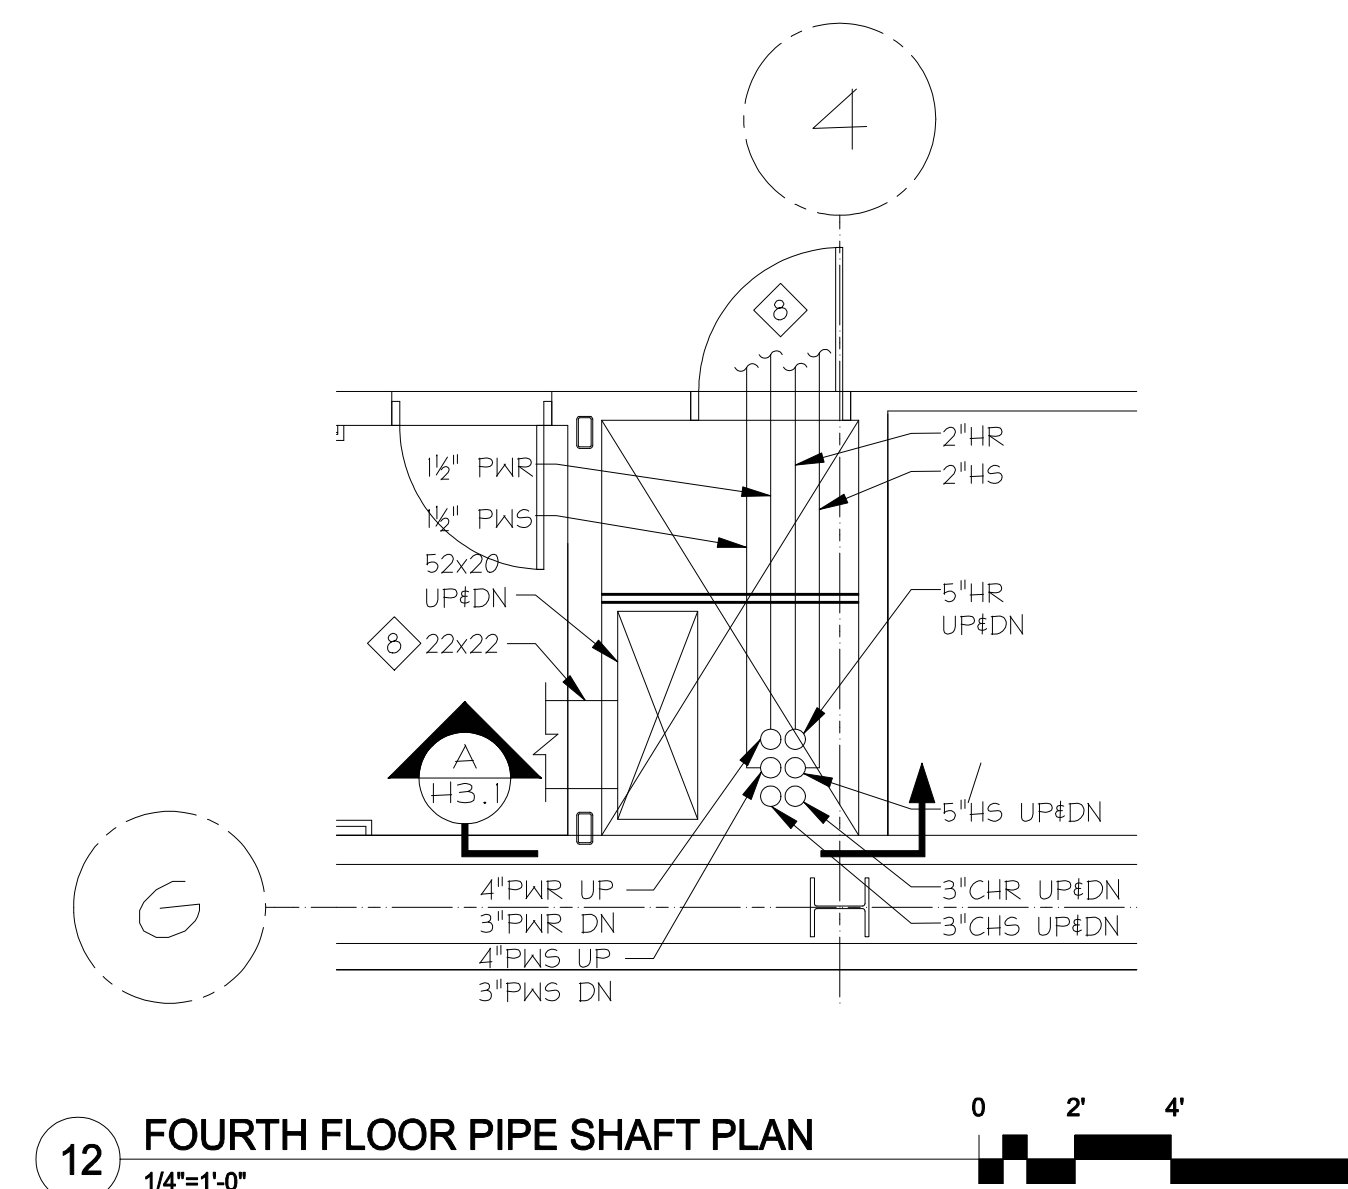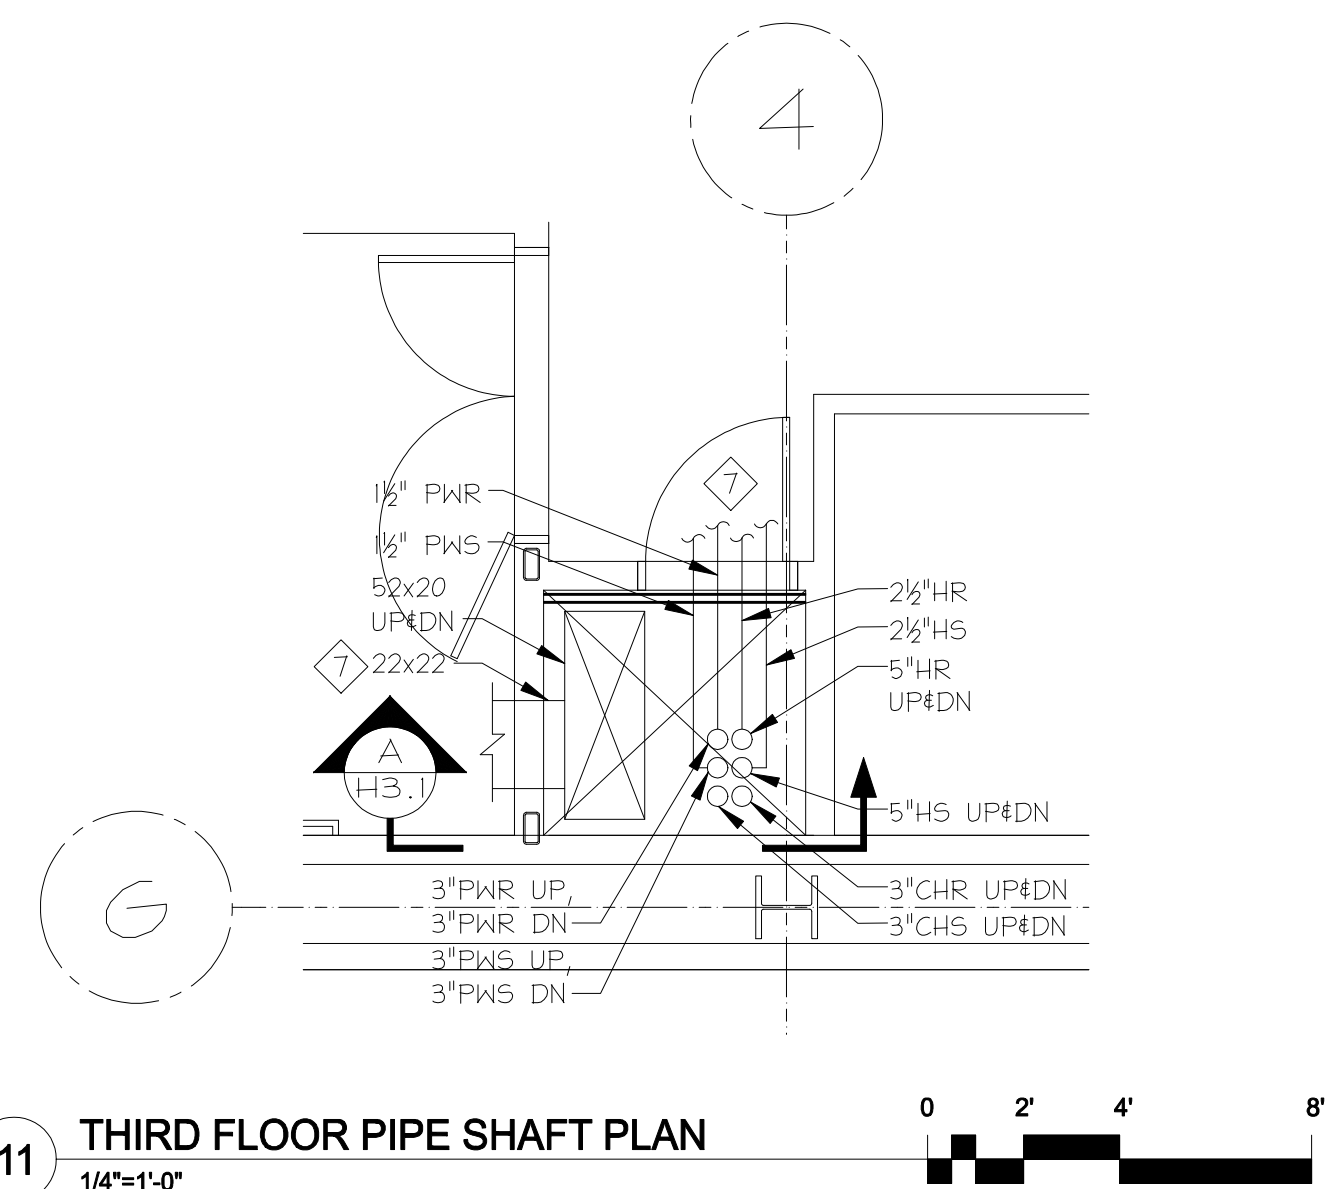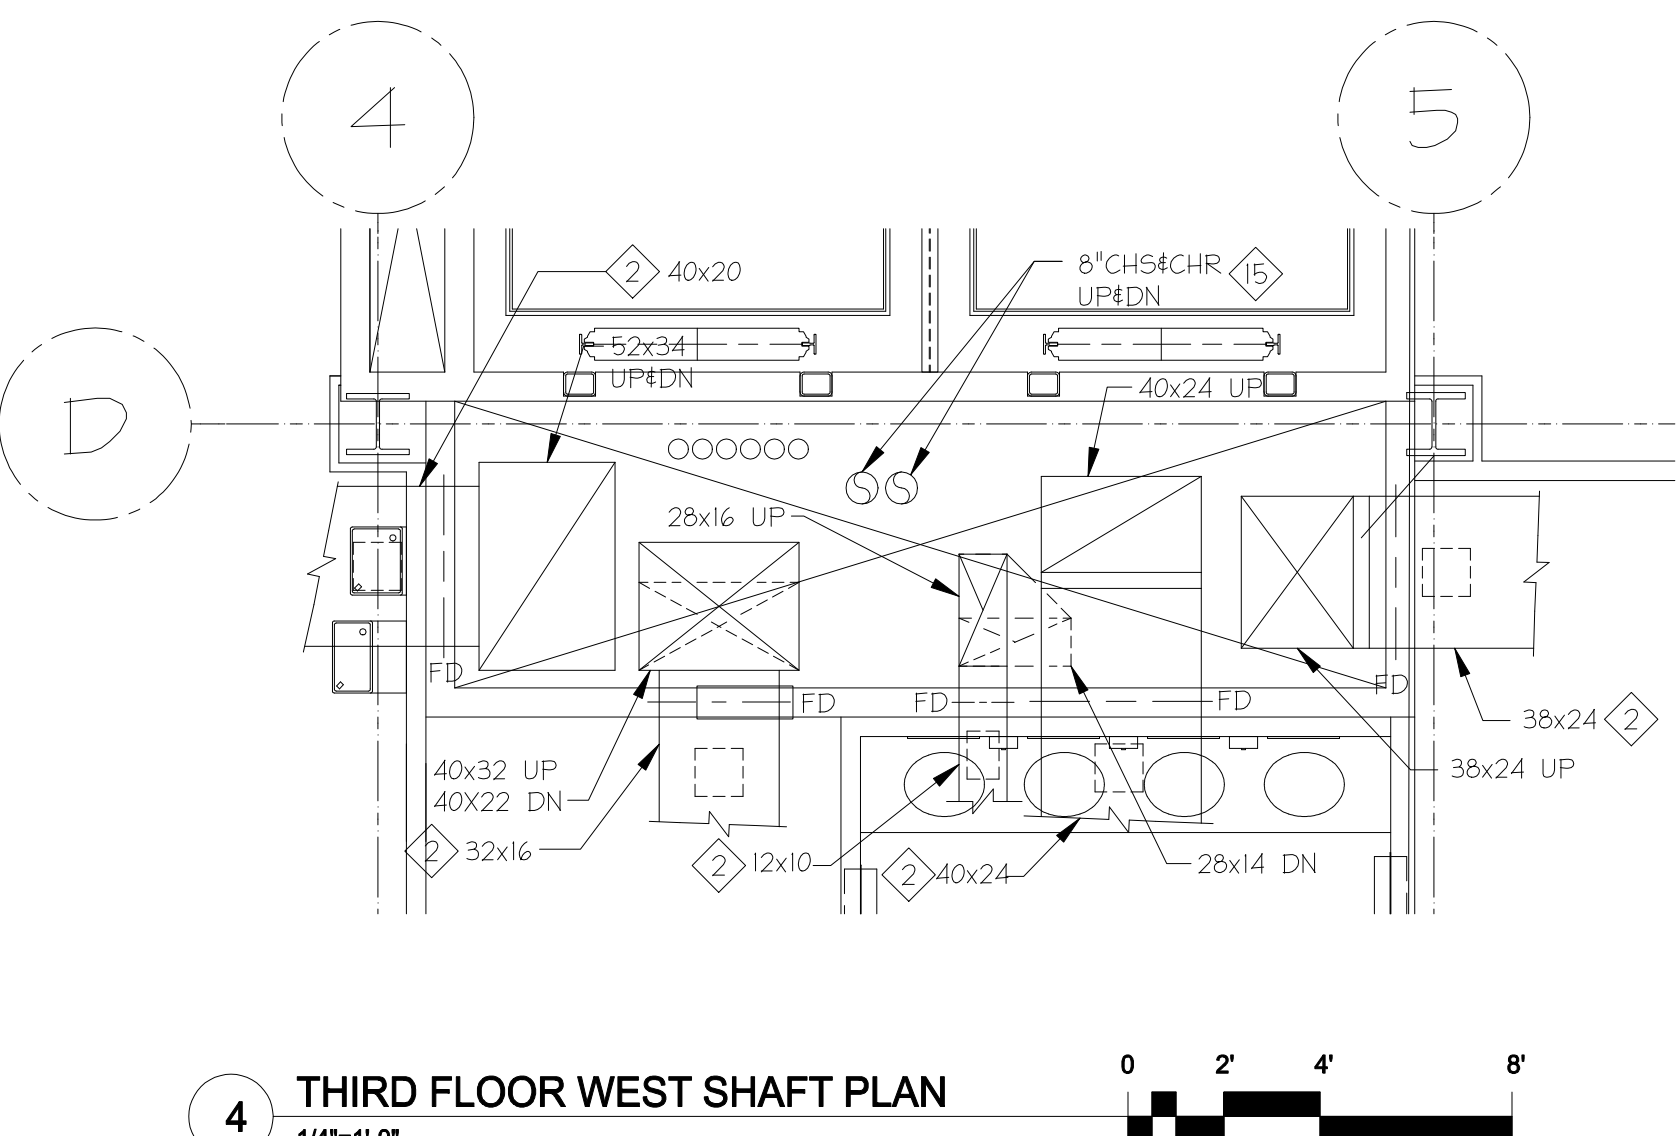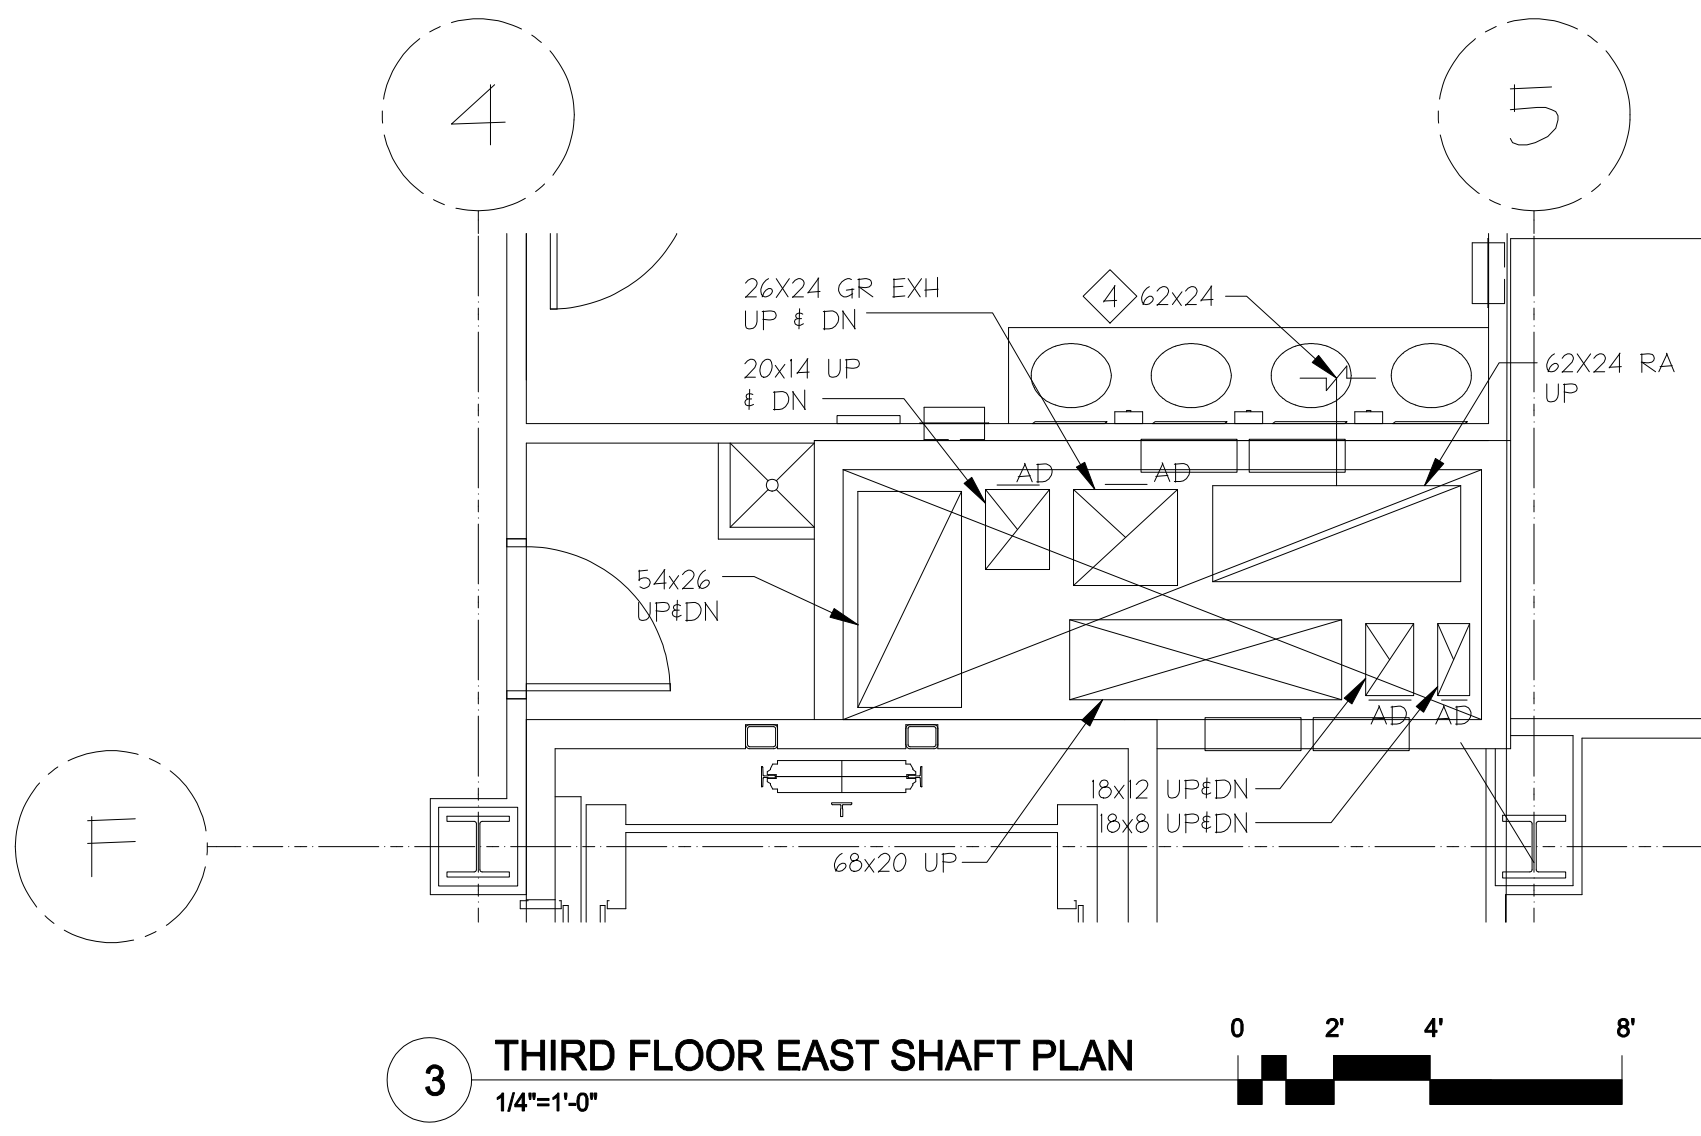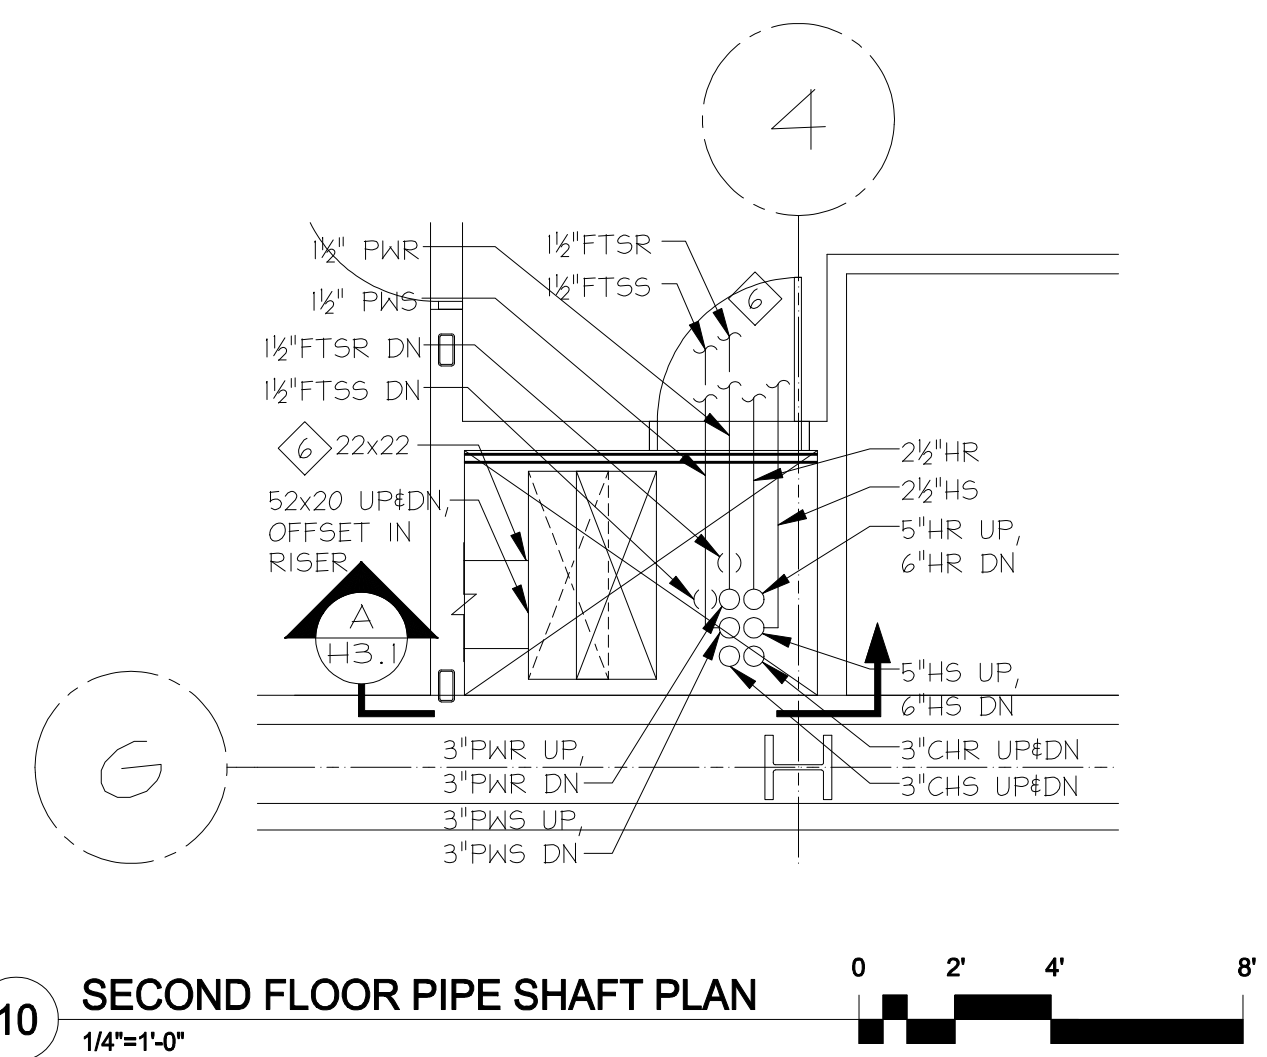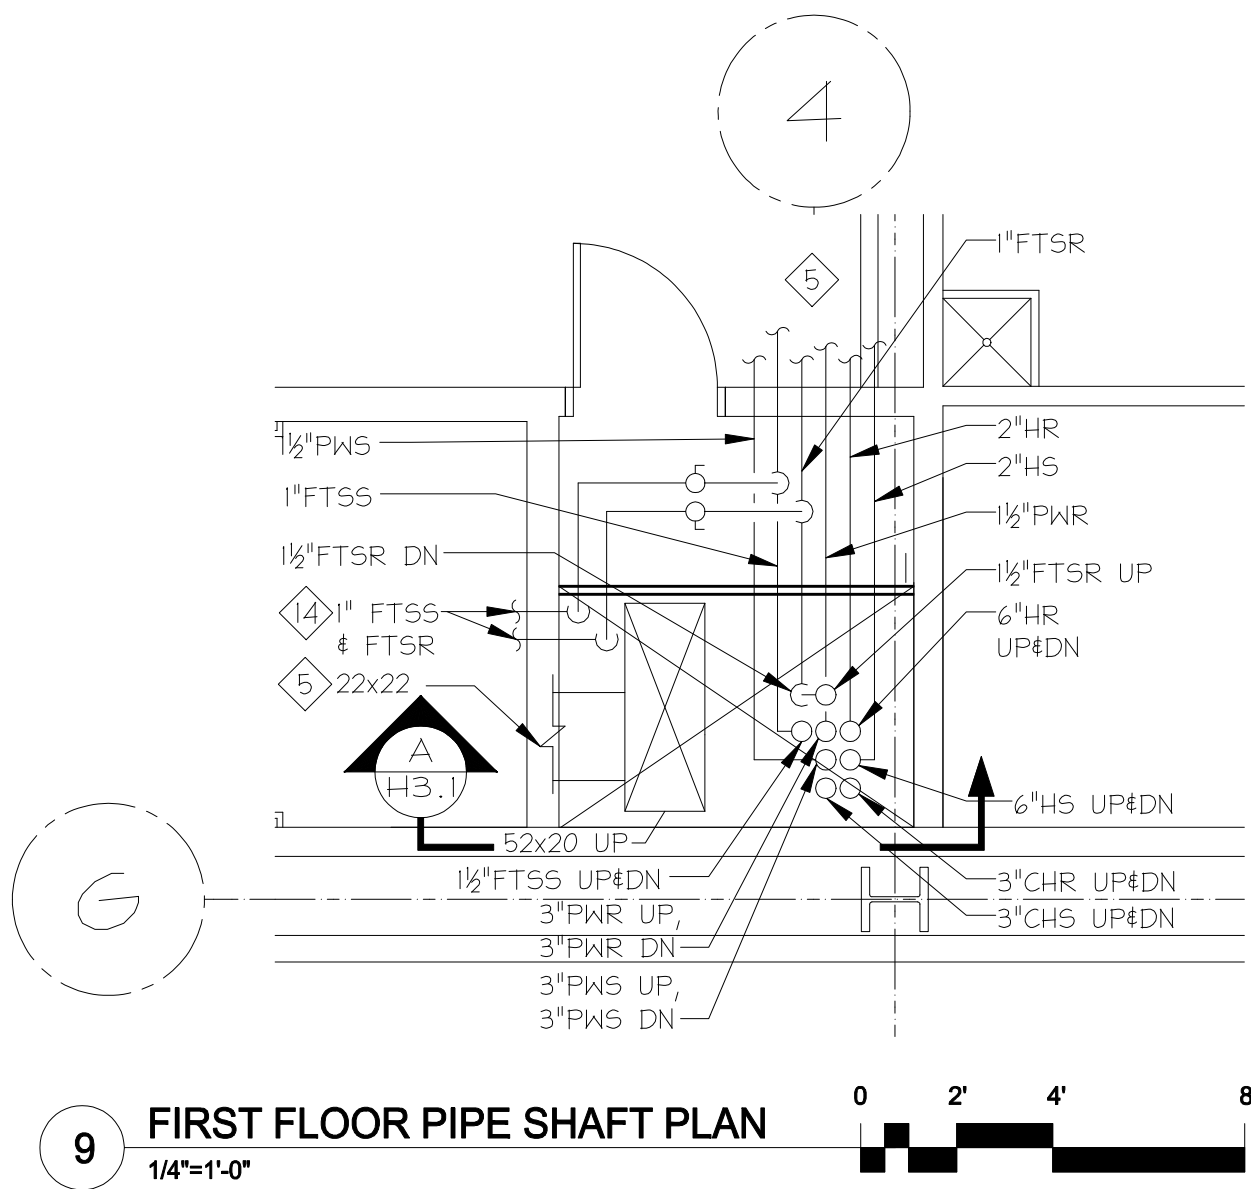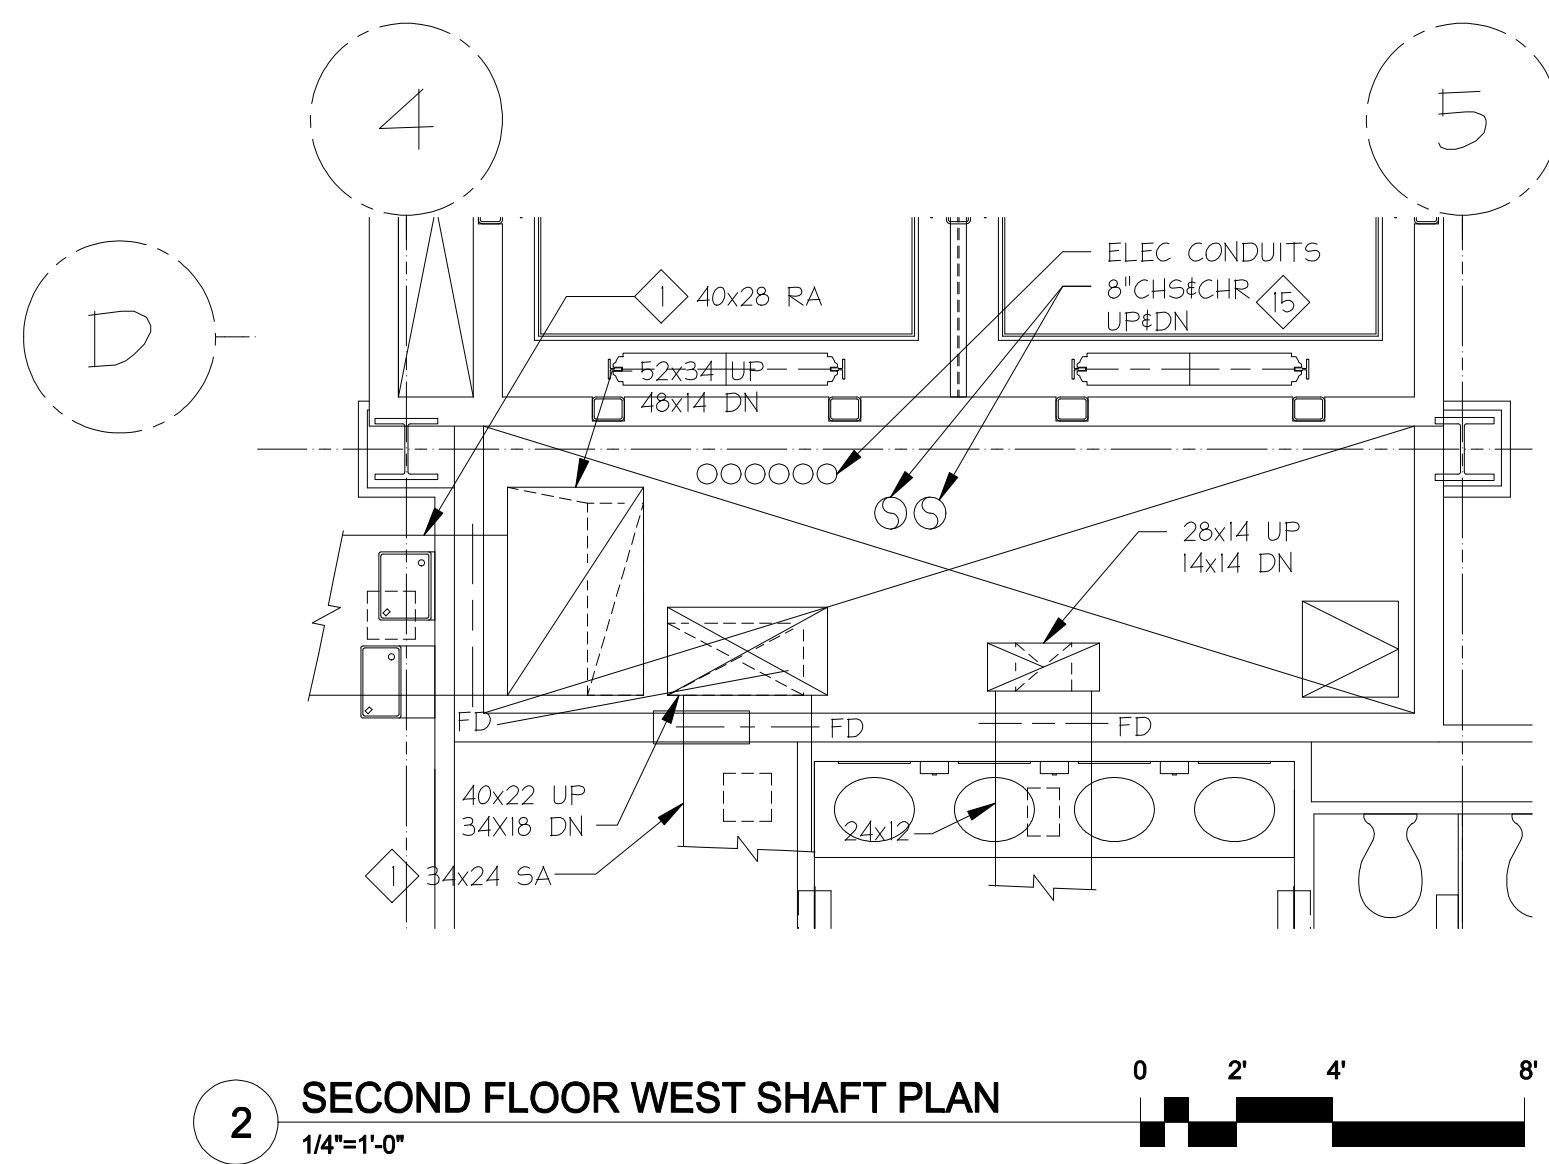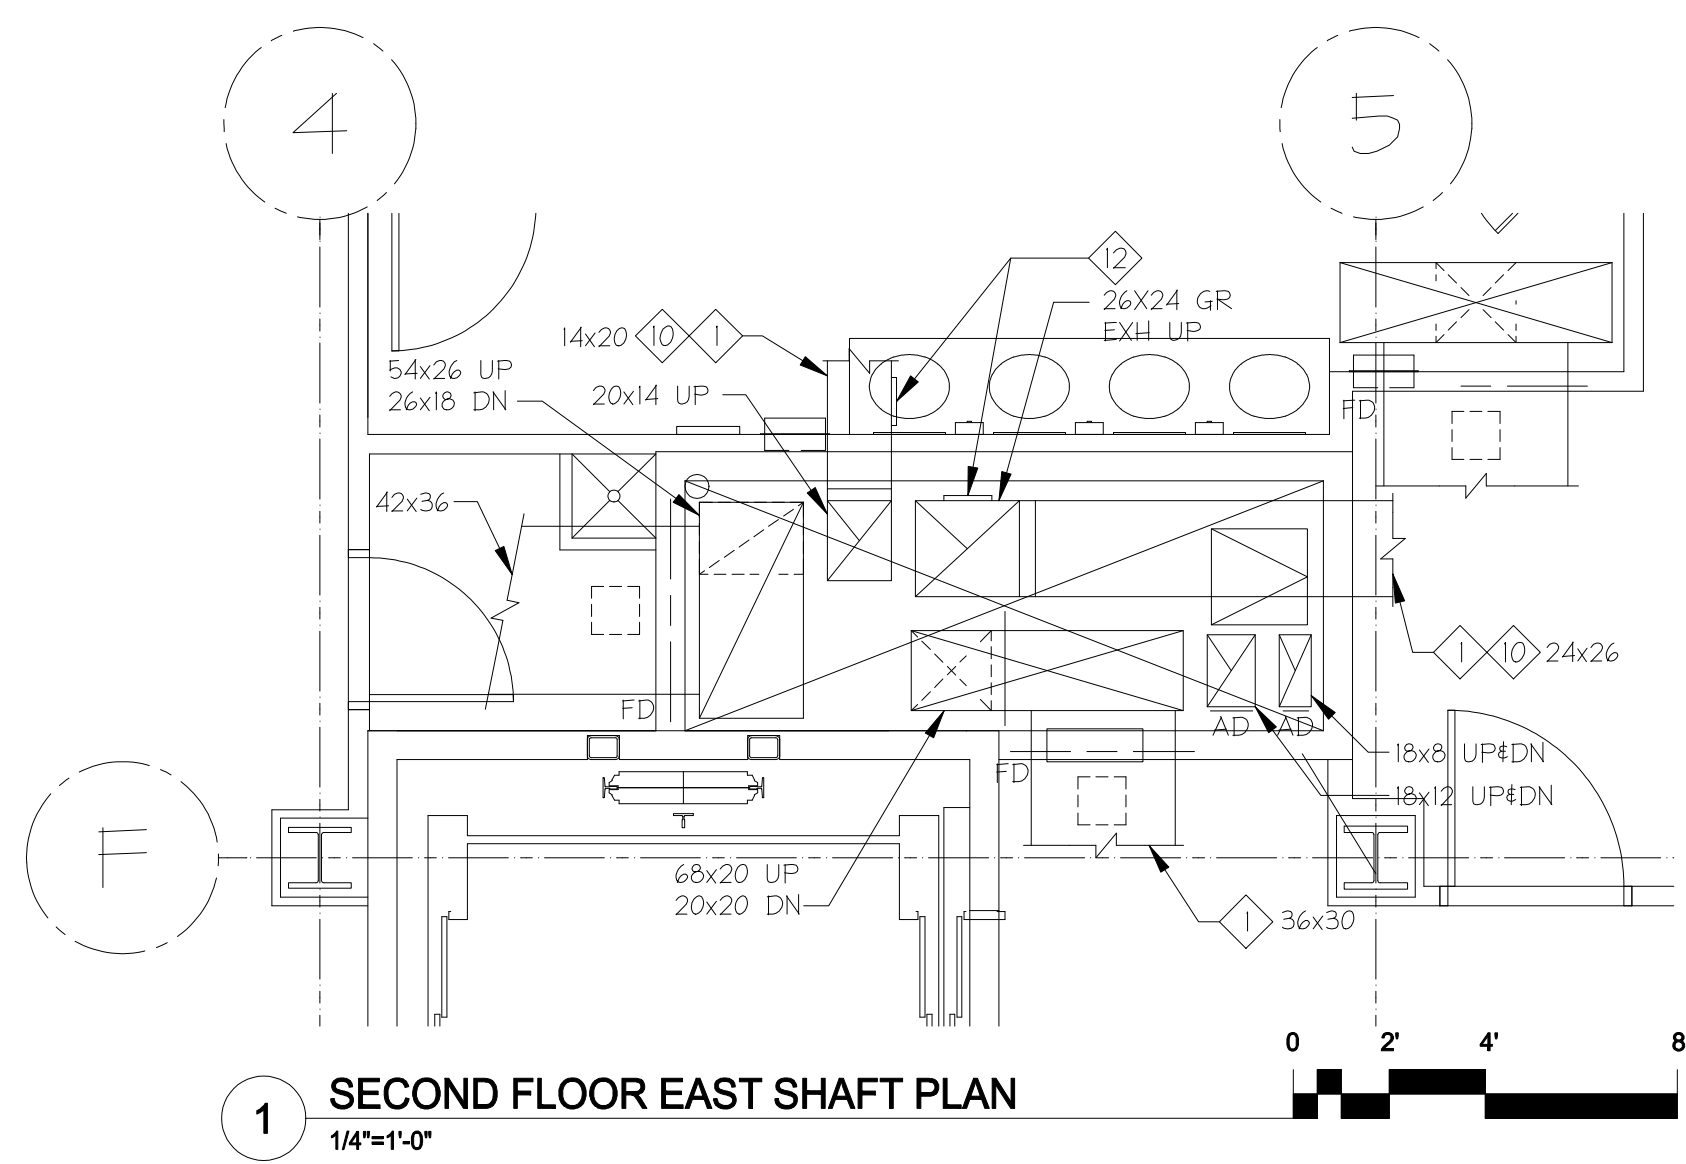

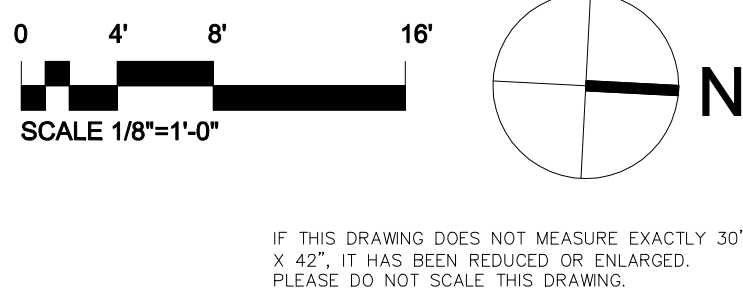

IF THIS DRAWING DOES NOT MEASURE EXACTLY 30" X 42", IT HAS BEEN REDUCED OR ENLARGED.
PLEASE DO NOT SCALE THIS DRAWING.

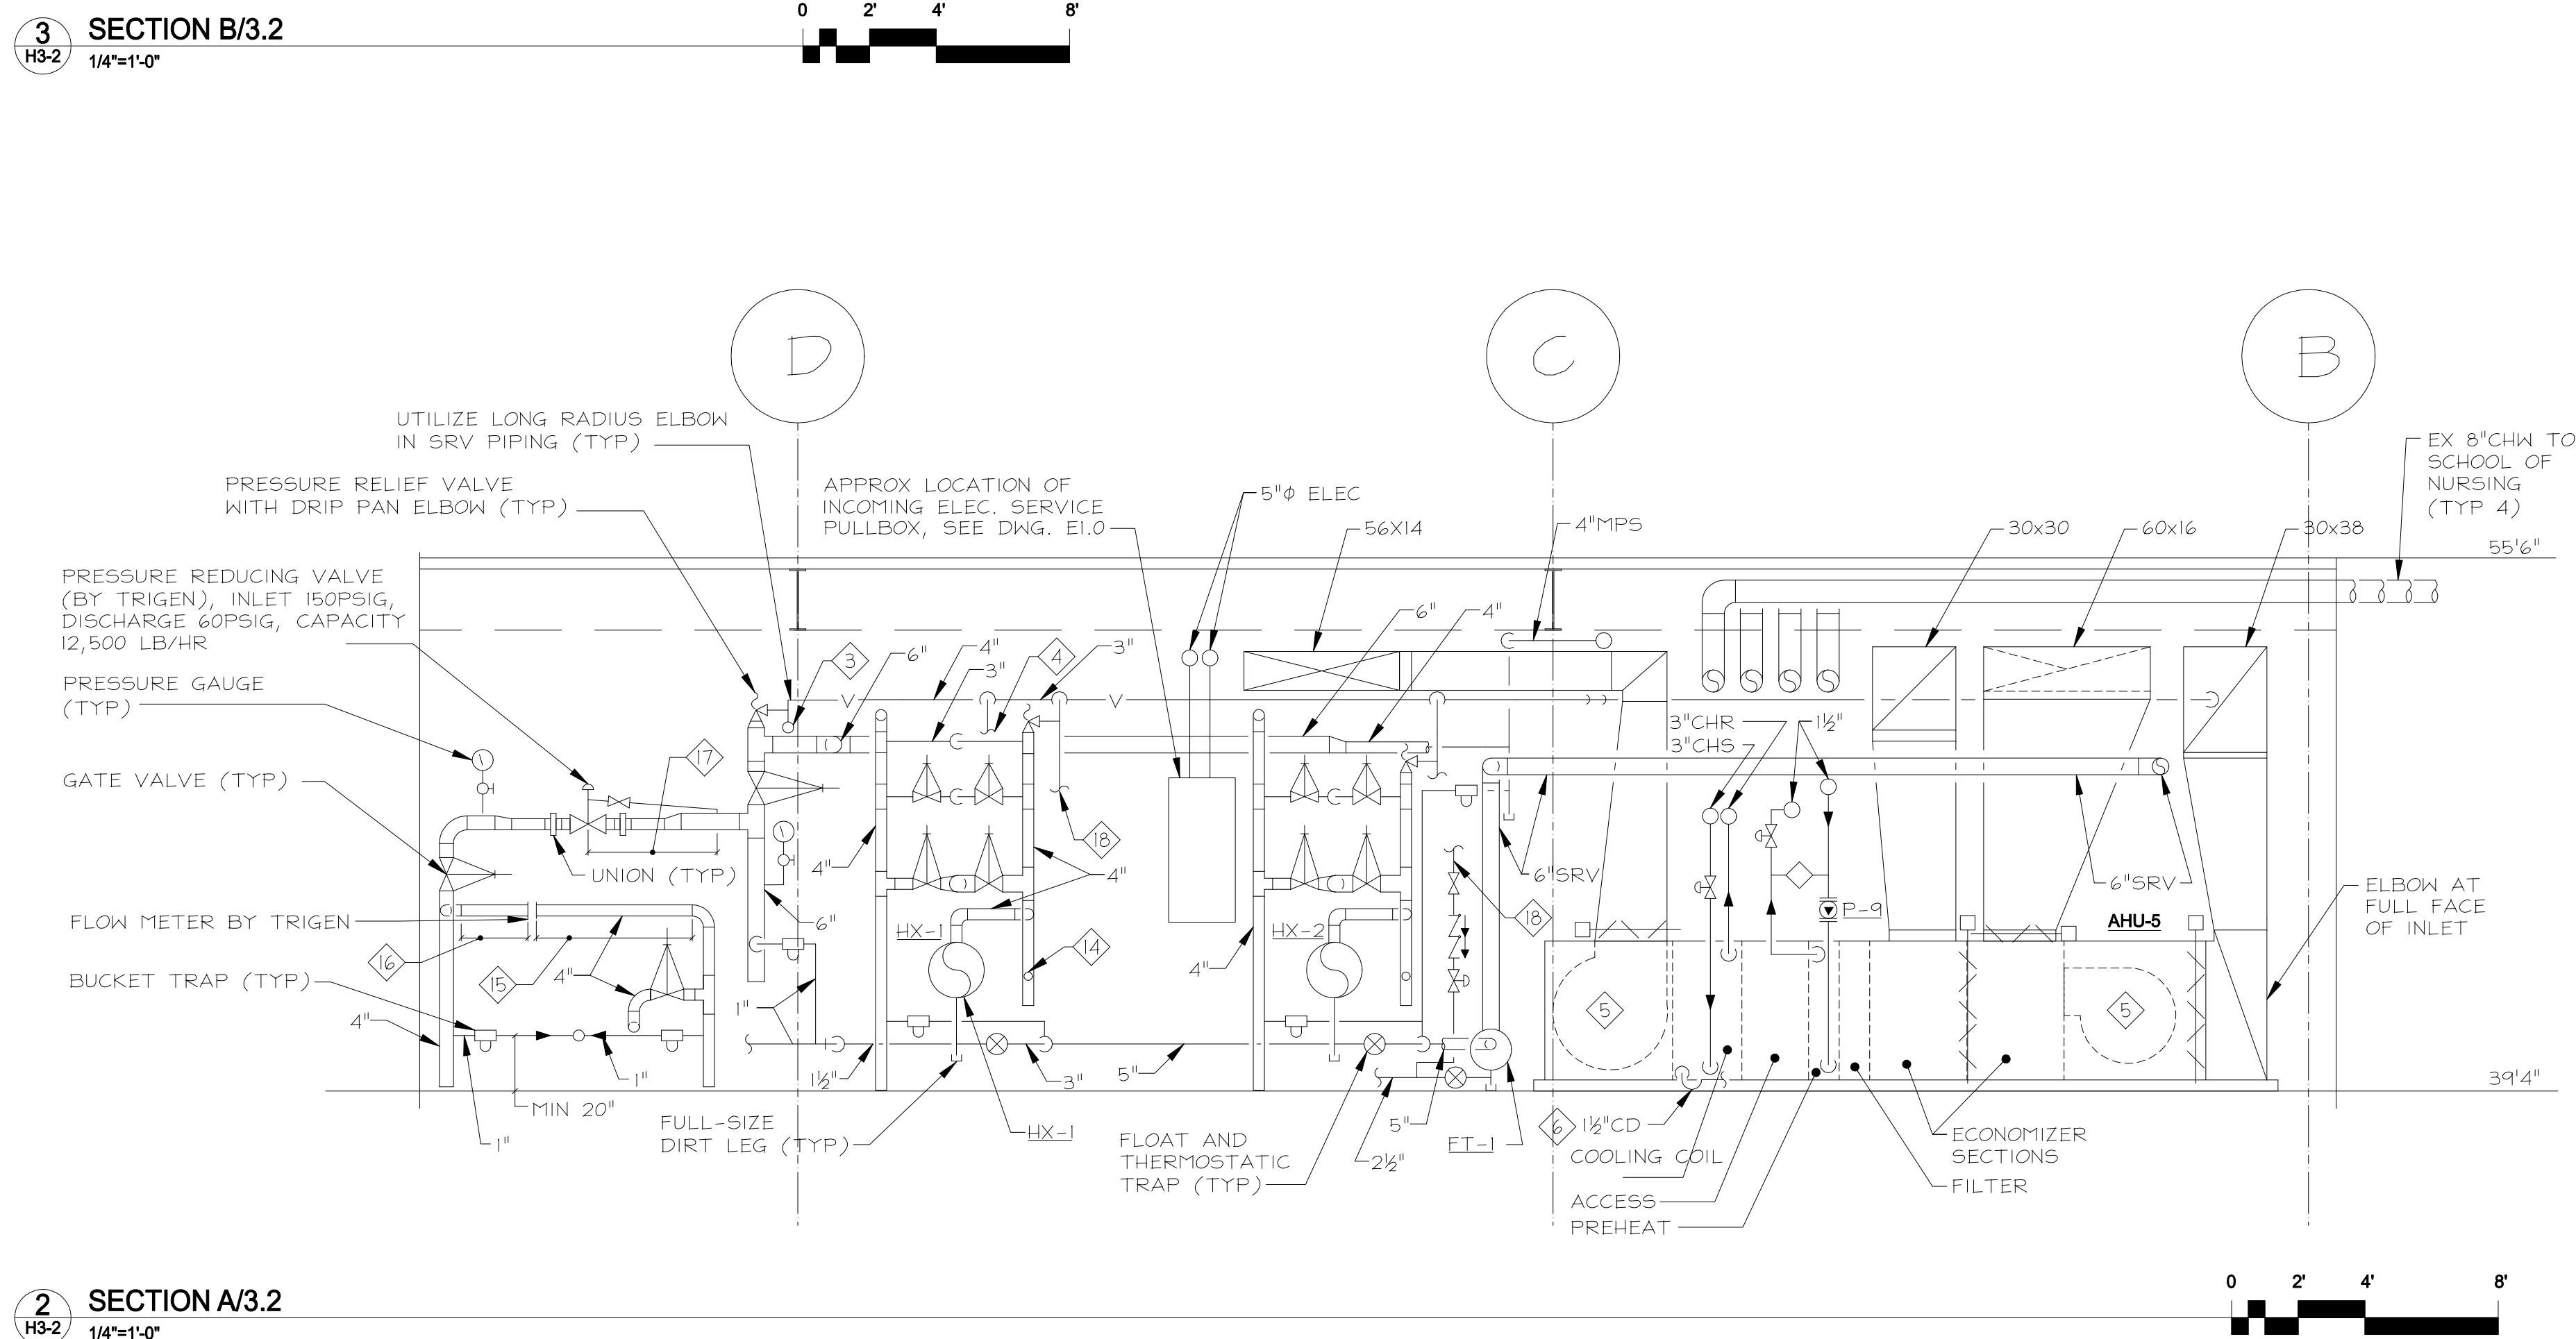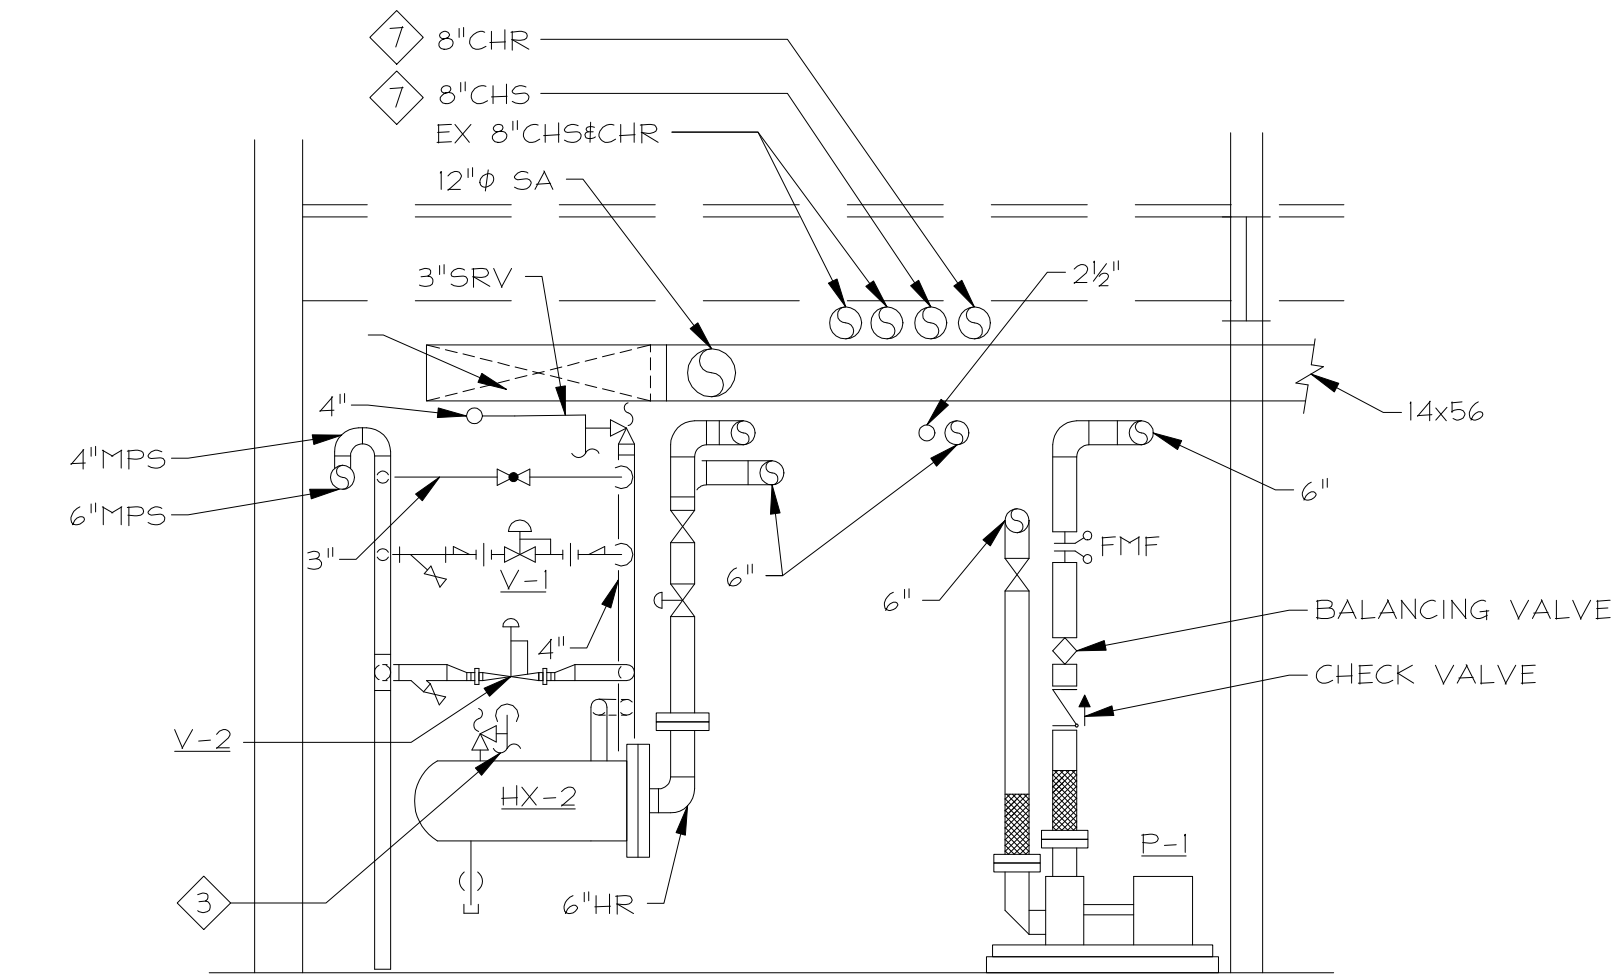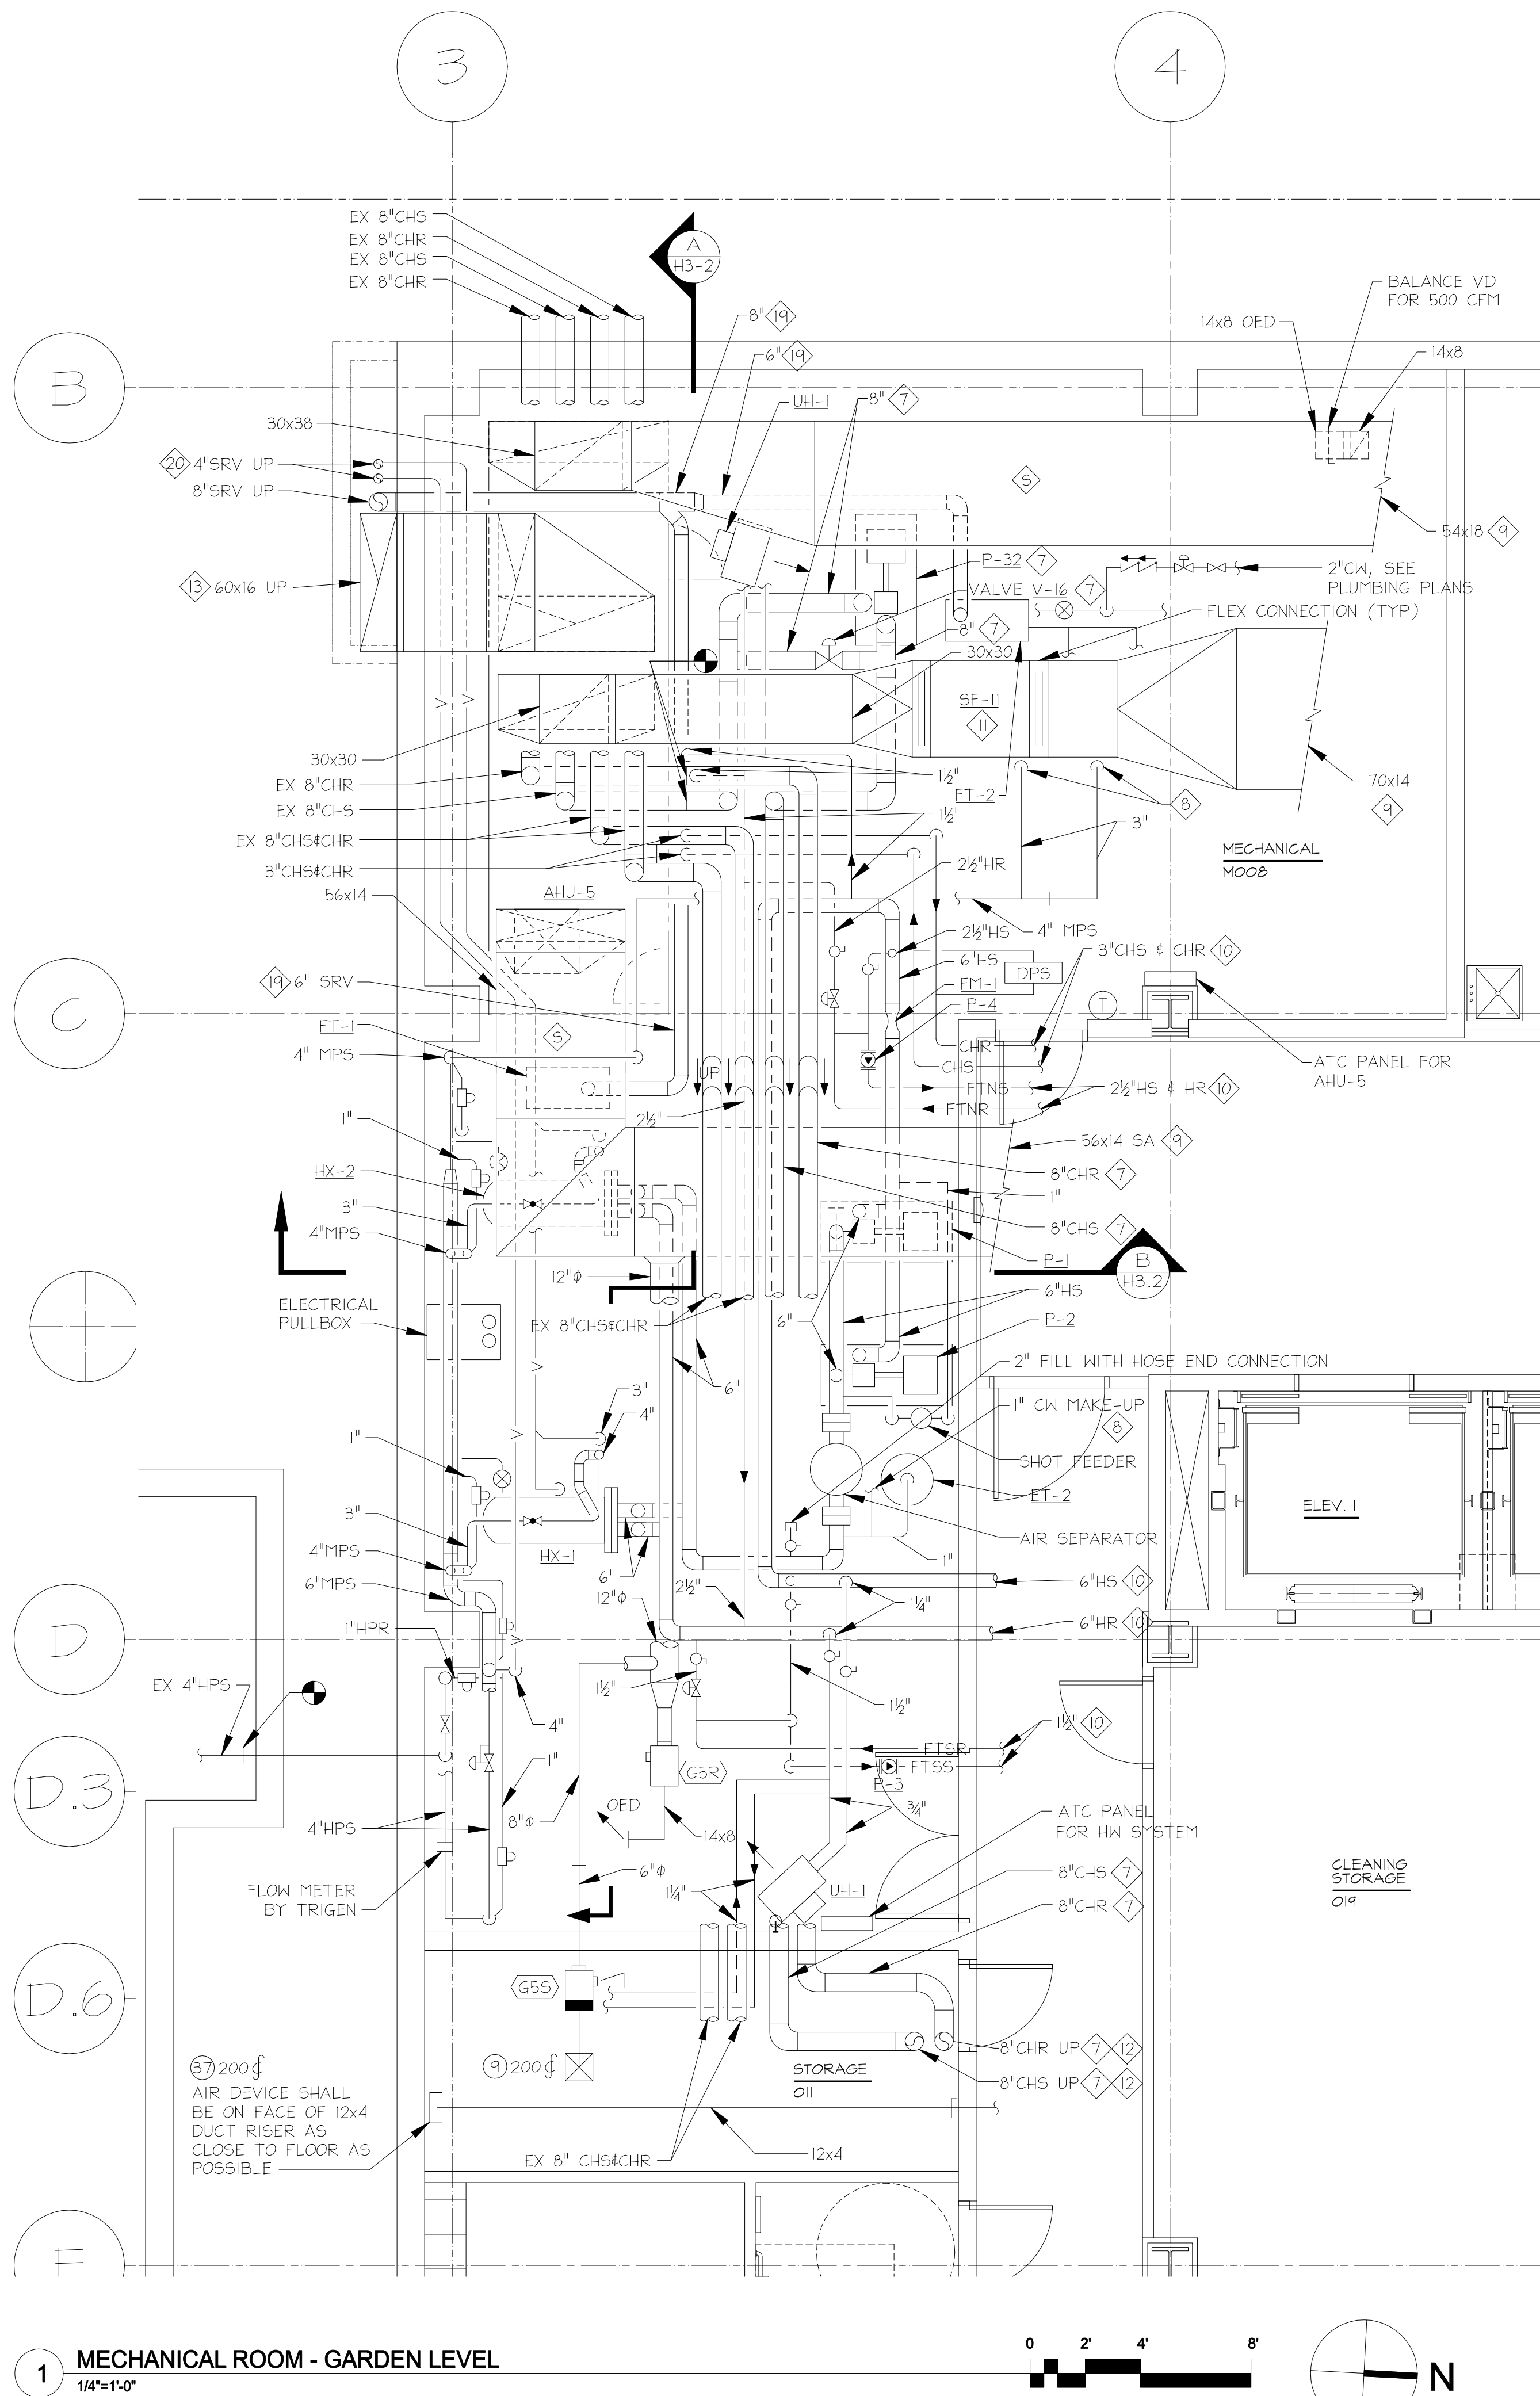

SPECIAL NOTES:

1. 1 1/2" CW MAKE UP.
2. 1 1/2" H54HR FOR UNIT HEATER.
3. PIPE FULL SIZE LIQUID DISCHARGE TO FLOOR DRAIN.
4. 3" SRV TO HX-1.
5. FAN SECTION WITH ACCESS DOOR.
6. PIPE TO NEAREST FLOOR DRAIN.
7. PROVIDE UNDER ALT#2.
8. 3" MPS TO DOMESTIC WATER HEATERS DWH-1 AND DWH-2.
9. FOR CONT. SEE DWG.H1.0.
10. FOR CONT. SEE DWG.H2.0.
11. MOTOR ON BOTTOM.
12. FOR CONT. SEE DWG.H2.1.
13. FOR CONT. SEE DWG. H1.1.
14. 1" MPR.
15. MINIMUM 50".
16. MINIMUM 24".
17. MINIMUM 54".
18. 2" CW, SEE PLUMBING PLANS FOR CONT.
19. SLOPE DOWN TOWARDS FLASH TANKS @ 1/8" PER LF.
20. PROVIDE 2" DRAIN AT BOTTOM OF RISER, PIPE TO NEAREST FLOOR DRAIN.



TIMBER COURT
127 ANDERSON STREET
PITTSBURGH, PA 15212-6801
(412) 321-5550
(412) 321-2431 FAX

ASSOCIATE ARCHITECT:



WBCM, - Architects
Whitney Bailey Cox &
Magnoni, LLC -
Consulting Engineers
849 Fairmount Ave. Suite 100
Baltimore, MD 21286 (410) 512-4500

Henry Adams, LLC.
Consulting Engineers



600 Baltimore Avenue
Baltimore, MD 21204-4079
410.296.6500
Fax 410.296.3156

Mullins
Engineering Co.

1221 ANNAPOLIS ROAD
ODDINGTON, MD 21113
410-519-0800
FAX 410-512-3971
MEC PROJECT NO. 0512300

20	1/29/10	RECORD DRAWING
19	8/4/09	BULLETIN #103
18	4/29/09	BULLETIN #108
17	4/20/09	BULLETIN #108R
16	3/30/09	BULLETIN #105
15	4/15/09	BULLETIN #095
14	3/2/09	BULLETIN #84
13	12/16/08	BULLETIN #82
12	12/7/08	BULLETIN #80
11	11/20/08	BULLETIN #79
10	11/19/08	BULLETIN #72 (rev)
9	10/20/08	BULLETIN #69
8	9/4/08	BULLETIN #63
7	7/28/08	BULLETIN #55
6	6/23/08	BULLETIN #51
5	05/23/08	COORD. DWGS RFI 163
4	05/09/08	BULLETIN #31
3	04/14/08	CBM-39
2	03/10/08	CBM-2
1	02/18/08	CBM-1
0	05/02/07	For Construction
Rev.	Date:	Comment:
Issued: May 2, 2007		

Campus Center

621 West Lombard Street
University of Maryland,
Baltimore
Baltimore, MD

Mech.
Room
Garden
Level

100% CONSTRUCTION
DOCUMENTS

UMB PROJECT NO. 99-311
WITW PROJECT NO. 70-4091
© WITW ARCHITECTS & (editin RE V0# yyyy)

H3.2

IF THIS DRAWING DOES NOT MEASURE EXACTLY 36" X 42", IT HAS BEEN REDUCED OR ENLARGED. PLEASE DO NOT SCALE THIS DRAWING.